

THOREAU BACA WELL CONNECTION

CONSTRUCTION PLANS



McKINLEY COUNTY, NEW MEXICO

FINAL DESIGN
FOR REVIEW

DRAWING INDEX

March 21

PROJECT DESCRIPTION:
CONSTRUCTION OF APPROXIMATELY 2,600 L.F. OF
4" PVC WATER LINE, AN ACCESS DRIVE AND A WELL
PUMP HOUSE WITH ASSOCIATED SITE PIPING

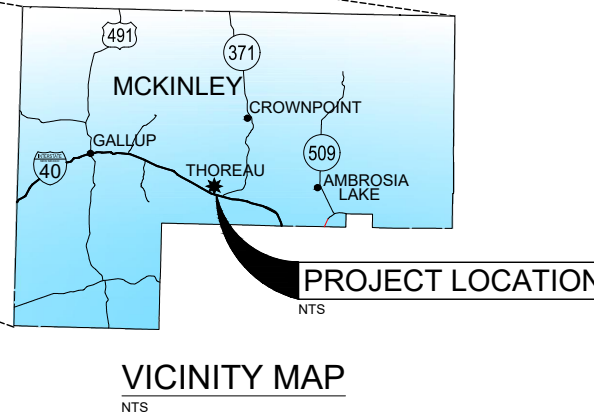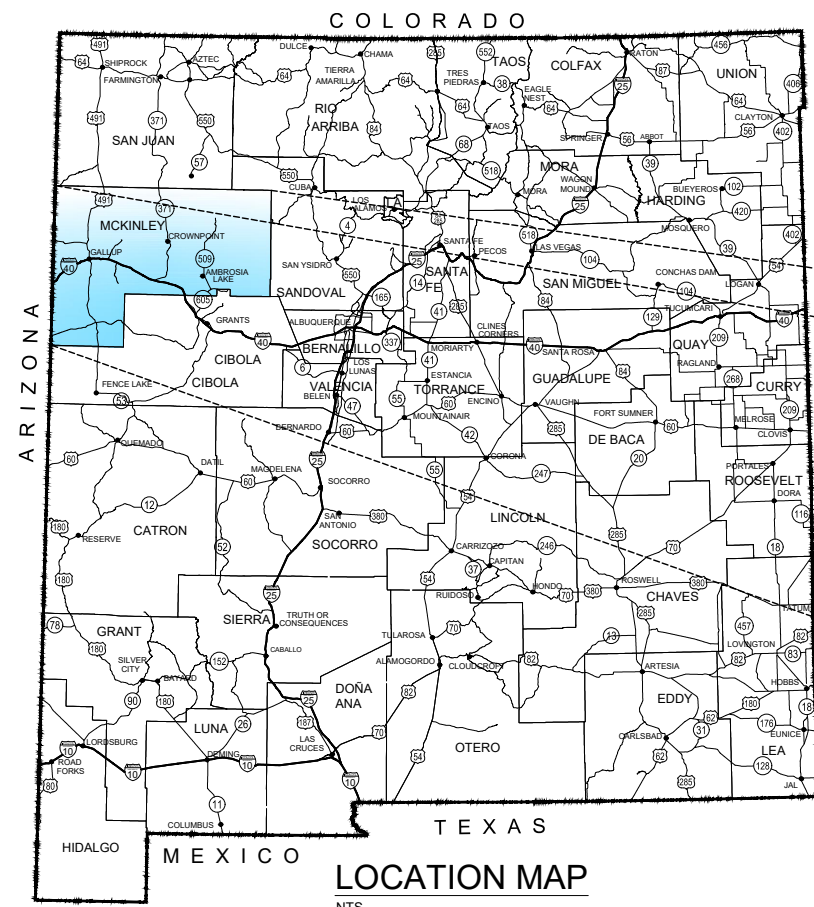

Sheet No.	Sheet Title
G-1	COVER AND DRAWING INDEX
G-2	GENERAL NOTES AND LEGEND
C-1	SURVEY CONTROL
C-2	SITE PLAN AND DRAWING KEY INDEX
C-3	WELL SITE ACCESS DRIVE
C-4	WELL EASEMENT AND SITE PLAN
C-5	WELL SITE AND GRADING PLAN
C-6	WELL SITE PIPING PLAN
C-7	PLAN & PROFILE STA 0+08.6 To STA 13+00
C-8	PLAN & PROFILE STA 13+00 To STA 26+11
DT-1	TRENCH, JOINT RESTRAINT AND MARKER DETAILS
DT-2	GATE VALVE AND THRUST BLOCK DETAILS
DT-3	GASLINE CROSSING DETAIL
DT-4	PIPE TRANSITION DETAILS
DT-5	2 INCH FLUSH VALVE AND AIR RELEASE VALVE DETAILS
DT-6	PUMPHOUSE PIPING DETAIL
DT-7	METER VAULT DETAIL
DT-8	GAS CHLORINATION DETAILS
DT-9	BUILDING AND PIPING DETAIL
DT-10	BUILDING DETAILS
DT-11	THOREAU WELL DESIGN DETAIL
DT-12	SONSELA WELL DESIGN DETAIL
DT-13	STANDARD WELL DETAILS
DT-14	FENCE DETAIL
DT-15	EROSION CONTROL DETAILS
E-1	PUMP HOUSE LAYOUT (1 OF 2)
E-2	PUMP HOUSE LAYOUT (2 OF 2)
E-3	SOFT START PUMP PANEL (1 OF 3)
E-4	SOFT START PUMP PANEL (2 OF 3)
E-5	SOFT START PUMP PANEL (3 OF 3)
E-6	PLC CONTROL PANEL (1 OF 6)
E-7	PLC CONTROL PANEL (2 OF 6)
E-8	PLC CONTROL PANEL (3 OF 6)
E-9	PLC CONTROL PANEL (4 OF 6)
E-10	PLC CONTROL PANEL (5 OF 6)
E-11	PLC CONTROL PANEL (5A OF 6)
E-12	PLC CONTROL PANEL (6 OF 6)

THESE DETAILED PLANS AND SPECIFICATIONS WERE PREPARED UNDER MY
DIRECTION AND SUPERVISION ON BEHALF OF SOUDER, MILLER & ASSOCIATES.

TORY TADANO, P.E. _____ DATE
PROJECT MANAGER

THE SEAL AND SIGNATURE OF THE PROFESSIONAL REGISTRANT IDENTIFIED
ON THIS COVER SHEET DOES NOT SUGGEST RESPONSIBLE CHARGE FOR ALL
SHEETS CONTAINED WITHIN THIS PACKAGE; PLAN SHEETS NOT SIGNED AND
SEALED ARE NOT THE RESPONSIBILITY OF THE PROFESSIONAL REGISTRANT
IDENTIFIED ON THIS COVER SHEET. PLEASE REFER TO PROFESSIONAL
REGISTRANTS IDENTIFIED ON INDIVIDUAL PLAN SHEETS.



Know what's below.
Call before you dig.

By	CHKD
Rev #	Date
Description	
SOUDER, MILLER & ASSOCIATES Engineering • Environmental • Geomatics Serving the Southwest & Rocky Mountains 5454 Venice Avenue NE, Suite D Albuquerque, NM 87113 Phone (505) 299-0942 Toll-Free (877) 299-0942 Fax (505) 293-3430 www.soudermiller.com	
THE NAVAJO NATION McKINLEY COUNTY, NEW MEXICO	
THOREAU BACA WELL CONNECTION SECTION 19, T. 14 N., R. 13 W. COVER AND DRAWING INDEX	
FINAL DESIGN FOR REVIEW	
THIS DRAWING IS INCOMPLETE AND NOT TO BE USED FOR CONSTRUCTION UNLESS IT IS STAMPED, SIGNED AND DATED	
Designed TTT	Drawn AAV
Checked JMG	
Date: March 2021	
Scale: Horiz: N/A Vert: N/A	
Project No: 6922883	
Sheet: G-1	

GENERAL NOTES

1. THE ENGINEER WAIVES ANY AND ALL RESPONSIBILITY AND IS NOT LIABLE FOR PROBLEMS THAT MAY ARISE FROM CONTRACTOR'S FAILURE TO FOLLOW THESE DRAWINGS, SPECIFICATIONS, AND THE DESIGN INTENT THEY CONVEY, OR FOR PROBLEMS ARISING FROM FAILURE TO OBTAIN AND/OR FOLLOW THE ENGINEER'S GUIDANCE WITH RESPECT TO ANY ERRORS, OMISSIONS, INCONSISTENCIES, AMBIGUITIES, OR CONFLICTS.
2. IT IS THE RESPONSIBILITY OF THE CONTRACTOR TO FAMILIARIZE HIMSELF WITH THE LOCATION OF ALL UTILITIES LOCATED WITHIN THE LIMITS OF CONSTRUCTION. THE GENERAL LOCATION OF KNOWN EXISTING UTILITIES HAS BEEN SHOWN ON THE CONSTRUCTION DRAWINGS TO INDICATE THAT CAUTION MUST BE EXERCISED WHEN WORKING IN THESE AREAS. IN MANY CASES THE EXACT LOCATION OF THE FACILITIES IS NOT KNOWN. THE CONTRACTOR SHALL BE RESPONSIBLE FOR LOCATING AND PROTECTING ALL OVERHEAD AND UNDERGROUND UTILITIES WITHIN THE VICINITY OF THE NEW CONSTRUCTION. PRIOR TO THE START OF CONSTRUCTION, THE CONTRACTOR, WORKING WITH THE RESPECTIVE UTILITY COMPANIES, SHALL ACCURATELY LOCATE AND MARK ALL BURIED FACILITIES, INCLUDING SERVICE LINES. ALL EQUIPMENT LABOR, ETC. NECESSARY TO PROPERLY LOCATE THE EXISTING UTILITIES SHALL BE FURNISHED BY THE CONTRACTOR, THE COST OF WHICH SHALL BE INCIDENTAL TO THE WORK.
3. CONTRACTOR SHALL REPAIR ANY EXISTING STRUCTURE OR UTILITY PIPELINE DAMAGED DURING THE EXECUTION OF THE PROJECT, AT NO ADDITIONAL COSTS TO THE OWNER.
4. CONTRACTOR IS SOLELY RESPONSIBLE FOR CONSTRUCTING THE PROJECT ACCORDING TO CURRENT NEW MEXICO STANDARD SPECIFICATIONS FOR PUBLIC WORKS CONSTRUCTION (NMSSPWC) AWWA SPECS AND NAVAJO NATION / NTUA STANDARDS, INCLUDING WHERE PARTICULAR WORK ITEMS ARE NOT SPECIFIED HEREIN.
5. CONTRACTOR SHALL COMPLY WITH ALL REQUIREMENTS AS SET FORTH IN THE TECHNICAL SPECIFICATIONS AND CONTRACT DOCUMENTS. IT SHALL BE THE RESPONSIBILITY OF THE CONTRACTOR TO CONTACT THE ENGINEER REGARDING ANY QUESTION ARISING FROM ANY ASPECT OF THIS PROJECT NOT SPECIFICALLY COVERED IN THE PLANS AND TECHNICAL SPECIFICATIONS, OR ANY CHANGES OR CORRECTIONS TO THE PLANS AND SPECS.
6. THESE DRAWINGS DO NOT INCLUDE NECESSARY COMPONENTS FOR CONSTRUCTION SAFETY, WHICH SHALL REMAIN WHOLLY THE RESPONSIBILITY OF THE CONTRACTOR. ALL WORK ON THIS PROJECT SHALL BE PERFORMED IN ACCORDANCE WITH APPLICABLE FEDERAL (OSHA), STATE, TRIBAL AND LOCAL LAWS, RULES AND REGULATIONS CONCERNING SAFETY AND HEALTH. ALL EXCAVATION, TRENCHING AND SHORING ACTIVITIES MUST BE CARRIED OUT IN ACCORDANCE WITH OSHA 29 CFR 1926, SUBPART P - EXCAVATIONS.
7. CONTRACTOR SHALL PROVIDE INGRESS AND EGRESS TO ANY LOCAL BUSINESSES AND RESIDENTS AS REQUIRED FOR THE DURATION OF THE PROJECT. THE CONTRACTOR SHALL ADVISE OF AND SCHEDULE ACCESS CLOSURES AT LEAST 24 HOURS IN ADVANCE WITH PROPERTY OWNERS AND THE ENGINEER.
8. THE DRAWINGS CONTAIN SPECIFIC EROSION CONTROL FEATURES DESIGNED BY THE ENGINEER TO PROTECT PROJECT FACILITIES FROM EROSION. THESE FEATURES ARE NOT DESIGNED TO PREVENT POLLUTION OF WATERWAYS DUE TO SEDIMENT. THE CONTRACTOR IS WHOLLY RESPONSIBLE TO PROVIDE A STORM WATER POLLUTION PREVENTION PLAN (SWPPP) AND IMPLEMENT THE BEST MANAGEMENT PRACTICES (BMPs) REQUIRED THEREIN, IN ADDITION TO THE FEATURES SHOWN ON THE DRAWINGS. ALL BID ITEMS REFERRING TO SPECIFIC EROSION CONTROL FEATURES, SUCH AS RIPRAP OR ROCK DAMS, ARE APPLICABLE ONLY TO FEATURES DESIGNED BY THE ENGINEER. A SEPARATE BID ITEM(S) IS PROVIDED FOR PREPARATION AND IMPLEMENTATION OF THE CONTRACTOR'S SWPPP.
9. ALL AREAS DISTURBED BY THE CONSTRUCTION ACTIVITIES OF THIS PROJECT SHALL BE RESTORED AND RE-GRADED IN A MANNER ACCEPTABLE TO THE OWNER, ENGINEER, AND LAND OWNER. ALL DISTURBED AREAS SHALL BE RE-SEEDING PER THE CONTRACT DOCUMENTS.
10. ALL PRESSURE RATINGS GIVEN HEREIN FOR PIPES, VALVES, FITTINGS AND OTHER COMPONENTS REFER TO COLD WATER WORKING PRESSURE RATING, UNLESS OTHERWISE NOTED.
11. CLEARANCES AT WATERLINE CROSSINGS ON PLAN AND PROFILE SHEETS CALLED OUT AS "MIN CLR" REFER TO MINIMUM CLEARANCE FROM EXISTING GASLINES AND WATERLINES TO WATERLINE.
12. ALL ELECTRICAL AND SCADA WORK DETAILED ON THESE PLANS TO BE PERFORMED UNDER CONTRACT SHALL, EXCEPT AS OTHERWISE STATED OR PROVIDED FOR, BE CONSTRUCTED IN ACCORDANCE WITH NAVAJO AREA INDIAN HEALTH SERVICE TECHNICAL PROVISIONS MOTOR CONTROL CENTER AND TANK CONTROL PANEL, MOST RECENT REVISION, REFERENCED WITHIN AS STANDARD SPECIFICATIONS.
13. ALL SCALES ARE BASED ON 11" x 17" SHEET SIZE.

CONTACT INFORMATION:

NAVAJO NATION WATER MANAGEMENT BRANCH (OWNER)

JASON JOHN (928) 729-4004

SOUDER, MILLER & ASSOCIATES (ENGINEER).

TORY TADANO, P.E (OFFICE) (505) 299-0942 (CELL) (505) 215-2807

NAVAJO TRIBAL UTILITY AUTHORITY (NTUA)




HEADQUARTERS (800) 528-5011

ABBREVIATIONS

ASHTO	AMERICAN ASSOCIATION OF STATE HIGHWAY AND TRANSPORTATION OFFICIALS
A.C.	ASPHALTIC CONCRETE
ACI	AMERICAN CONCRETE INSTITUTE
AC.	ACRE
AC-FT.	ACRE FEET
AISC	AMERICAN INSTITUTE OF STEEL CONSTRUCTION
ALIGN.	ALIGNMENT
ALUM	ALUMINUM
AMSL	ABOVE MEAN SEA LEVEL
ANSI	AMERICAN NATIONAL STANDARDS INSTITUTE
APPROX.	APPROXIMATE
ARV	AIR RELEASE VALVE
ASTM	AMERICAN SOCIETY FOR TESTING AND MATERIALS
AWG	AMERICAN WIRE GAUGE
AWWA	AMERICAN WATER WORKS ASSOCIATION
BFV	BUTTERFLY VALVE
BIA	BUREAU OF INDIAN AFFAIRS
B.G.S.	BELOW GROUND SURFACE
BLDG	BUILDING
BLM	BUREAU OF LAND MANAGEMENT
BV	BALL VALVE
BVCE	BEGIN VERTICAL CURVE ELEVATION
BVCS	BEGIN VERTICAL CURVE STATION
CL	CENTERLINE
CFS	CUBIC FEET PER SECOND
CI	CAST IRON
CLR.	CLEARANCE
CMP	CORRUGATED METAL PIPE
COMM.	COMMUNICATION
CONC.	CONCRETE
CONST.	CONSTRUCTION
CONT.	CONTINUOUS
CONT.	CONTINUED
COR.	CORNER
COUP.	COUPLING
CP	CONTROL POINT
CTR	CENTER
CU	CUBIC
CY	CUBIC YARD
DI	DUCTILE IRON
DIA	DIAMETER
DIMS	DIMENSIONS
DR	DIMENSION RATIO
DRIVEWAY	DRIVEWAY
E	EAST
E	EASTING
EA.	EACH
ED.	EDITION
EG	EXISTING GRADE
ELEC.	ELECTRICAL
EL., ELEV.	ELEVATION
EOP	EDGE OF PAVEMENT
EQ.	EQUAL
ESMT.	EASEMENT
EVCE	END VERTICAL CURVE ELEVATION
EVCS	END VERTICAL CURVE STATION
EX, EXIST.	EXISTING
FBE	FUSION BONDED EPOXY
FF	FINISHED FLOOR
FFE	FINISHED FLOOR ELEVATION
FG	FINISHED GRADE
FIG.	FIGURE
FL	FLANGE
FND.	FOUND
FNPT	FEMALE NATIONAL PIPE THREAD
FRP	FIBER REINFORCED PLASTIC
FT.	FEET
FV	FLUSH VALVE
GA.	GAUGE
GALV.	GALVANIZED
GI	GALVANIZED IRON
GPM	GALLONS PER MINUTE
GV	GATE VALVE
HDD	HORIZONTAL DIRECTIONAL DRILLING
HDPE	HIGH DENSITY POLYETHYLENE
HORIZ.	HORIZONTAL
HP	HORSEPOWER
HT	HEIGHT
HWY	HIGHWAY
I.A.	INDIAN ALLOTMENT
I.D.	INNER DIAMETER
I.E.	THAT IS, FOR EXAMPLE
IN.	INCH
INV	INVERT
IPS	IRON PIPE SIZE
KSI	KILO POUNDS PER SQUARE INCH

AT	LATITUDE
L LEN	LENGTH
LF	LINEAR FEET
LT	LEFT
LONG	LONGITUDE
LVC	LENGTH VERTICAL CURVE
MANUF	MANUFACTURER
MAX.	MAXIMUM
MIL	ONE THOUSANDTHS OF AN INCH
MIN.	MINIMUM
M.J	MECHANICAL JOINT
MNPT	MALE NATIONAL PIPE THREAD
M.S.L.	MEAN SEA LEVEL
N	NORTH
N	NORTHING
NEC	NATIONAL ELECTRICAL CODE
NG	NATURAL GAS
NM	NEW MEXICO
NMDOT	NEW MEXICO DEPARTMENT OF TRANSPORTATION
NMED	NEW MEXICO ENVIRONMENT DEPARTMENT
NN	NAVAJO NATION
NO.	NUMBER
NPT	NATIONAL PIPE THREAD
NTS	NOT TO SCALE
OAE	OR APPROVED EQUAL
O.C.	ON CENTER
O.C.E.W.	ON CENTER EACH WAY
O.D.	OUTER DIAMETER
OHE	OVERHEAD ELECTRICAL
PE	PLAIN END
P.G.P.	PER GRADING PLAN
PI	POINT OF INFLECTION
PRV	PRESSURE REDUCING VALVE
PSF	POUNDS PER SQUARE FOOT
PSI	POUNDS PER SQUARE INCH
PVC	POLYVINYL CHLORIDE
PVI	POINT VERTICAL INFLECTION
PVT	PRIVATE
Q	FLOW
QTY.	QUANTITY
R	RADIUS
R-	RANGE
REF	REFERENCE
RO	ROUGH OPENING
ROW	RIGHT OF WAY
RT	RIGHT
S	SOUTH
SCH	SCHEDULE
SDR	STANDARD DIMENSION RATIO
SEC.	SECTION
SF	SAFETY FACTOR
SHT	SHEET
SPECS.	SPECIFICATIONS
SS	STAINLESS STEEL
STA	STATION
STD.	STANDARD
SW	SIDEWALK
T	TOWNSHIP
TBD	TO BE DETERMINED
TDH	TOTAL DYNAMIC HEAD
TELE.	TELEPHONE
TEMP.	TEMPORARY
THK	THICK
TNT	NAVAJO TRIBAL TRUST
T.O.	TOP OF
TOC	TOP OF CONCRETE
TRANS	TRANSFORMER
TW	TOP OF WALL
TYP	TYPICAL
UGE	UNDERGROUND ELECTRIC
USGS	UNITED STATES GEOLOGICAL SURVEY
V	VOLUME
VB	VACUUM BREAKER
VERT.	VERTICAL
VLV	VALVE
VR	VACUUM RELIEF
W	WATER
W	WEST
W/	WITH
WL	WATERLINE
WP	WORKING PRESSURE
WT	WALL THICKNESS
WV	WATER VALVE
YDS	YARDS
Z	ZENITH

 
 
 
LEGEND

	EXISTING WATER VALVE
	PRESSURE REDUCING VALVE
	SANITARY SEWER MANHOLE
	POWER POLE
	GUY ANCHOR
	ELECTRIC METER
	LIGHT POLE
	BOLLARD
	SANITARY SEWER CLEAN OUT
	SURVEY CONTROL
	BUILDING
	ROAD EDGE
	CONTOUR MAJOR
	CONTOUR MINOR
	CULTURALLY SENSITIVE AREA
	FENCE
	FENCE
	OVERHEAD ELECTRIC
	UNDERGROUND ELECTRIC
	OVERHEAD TELEPHONE LINE
	UNDERGROUND TELEPHONE LINE
	WATER LINE
	GAS LINE
	WASH

LEGEND

	WATER LINE
	FENCE
	OVERHEAD ELECTRIC
	UNDERGROUND ELECTRIC
	ACCESS DRIVE
	PIPE CASING
	GATE VALVE
	AIR RELEASE VALVE ASSEMBLY
	GATE
	POWER POLE
	CONTOUR MAJOR
	CONTOUR MINOR
	RIP RAP
	GRAVEL OVER BASE COURSE
	DIRECTION OF FLOW
	EASEMENT
	MATCH LINE

P:\BACA-Previtt (6022883)\BACA Thoreau Well Connection\CADD\DWG\6022883-Thoreau Well Conn Survey Control.dwg
3/4/2021 1:45:10 PM JDC

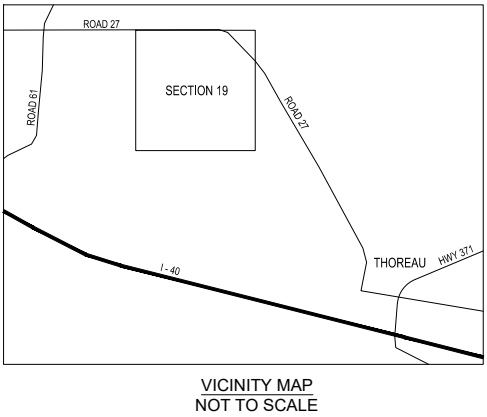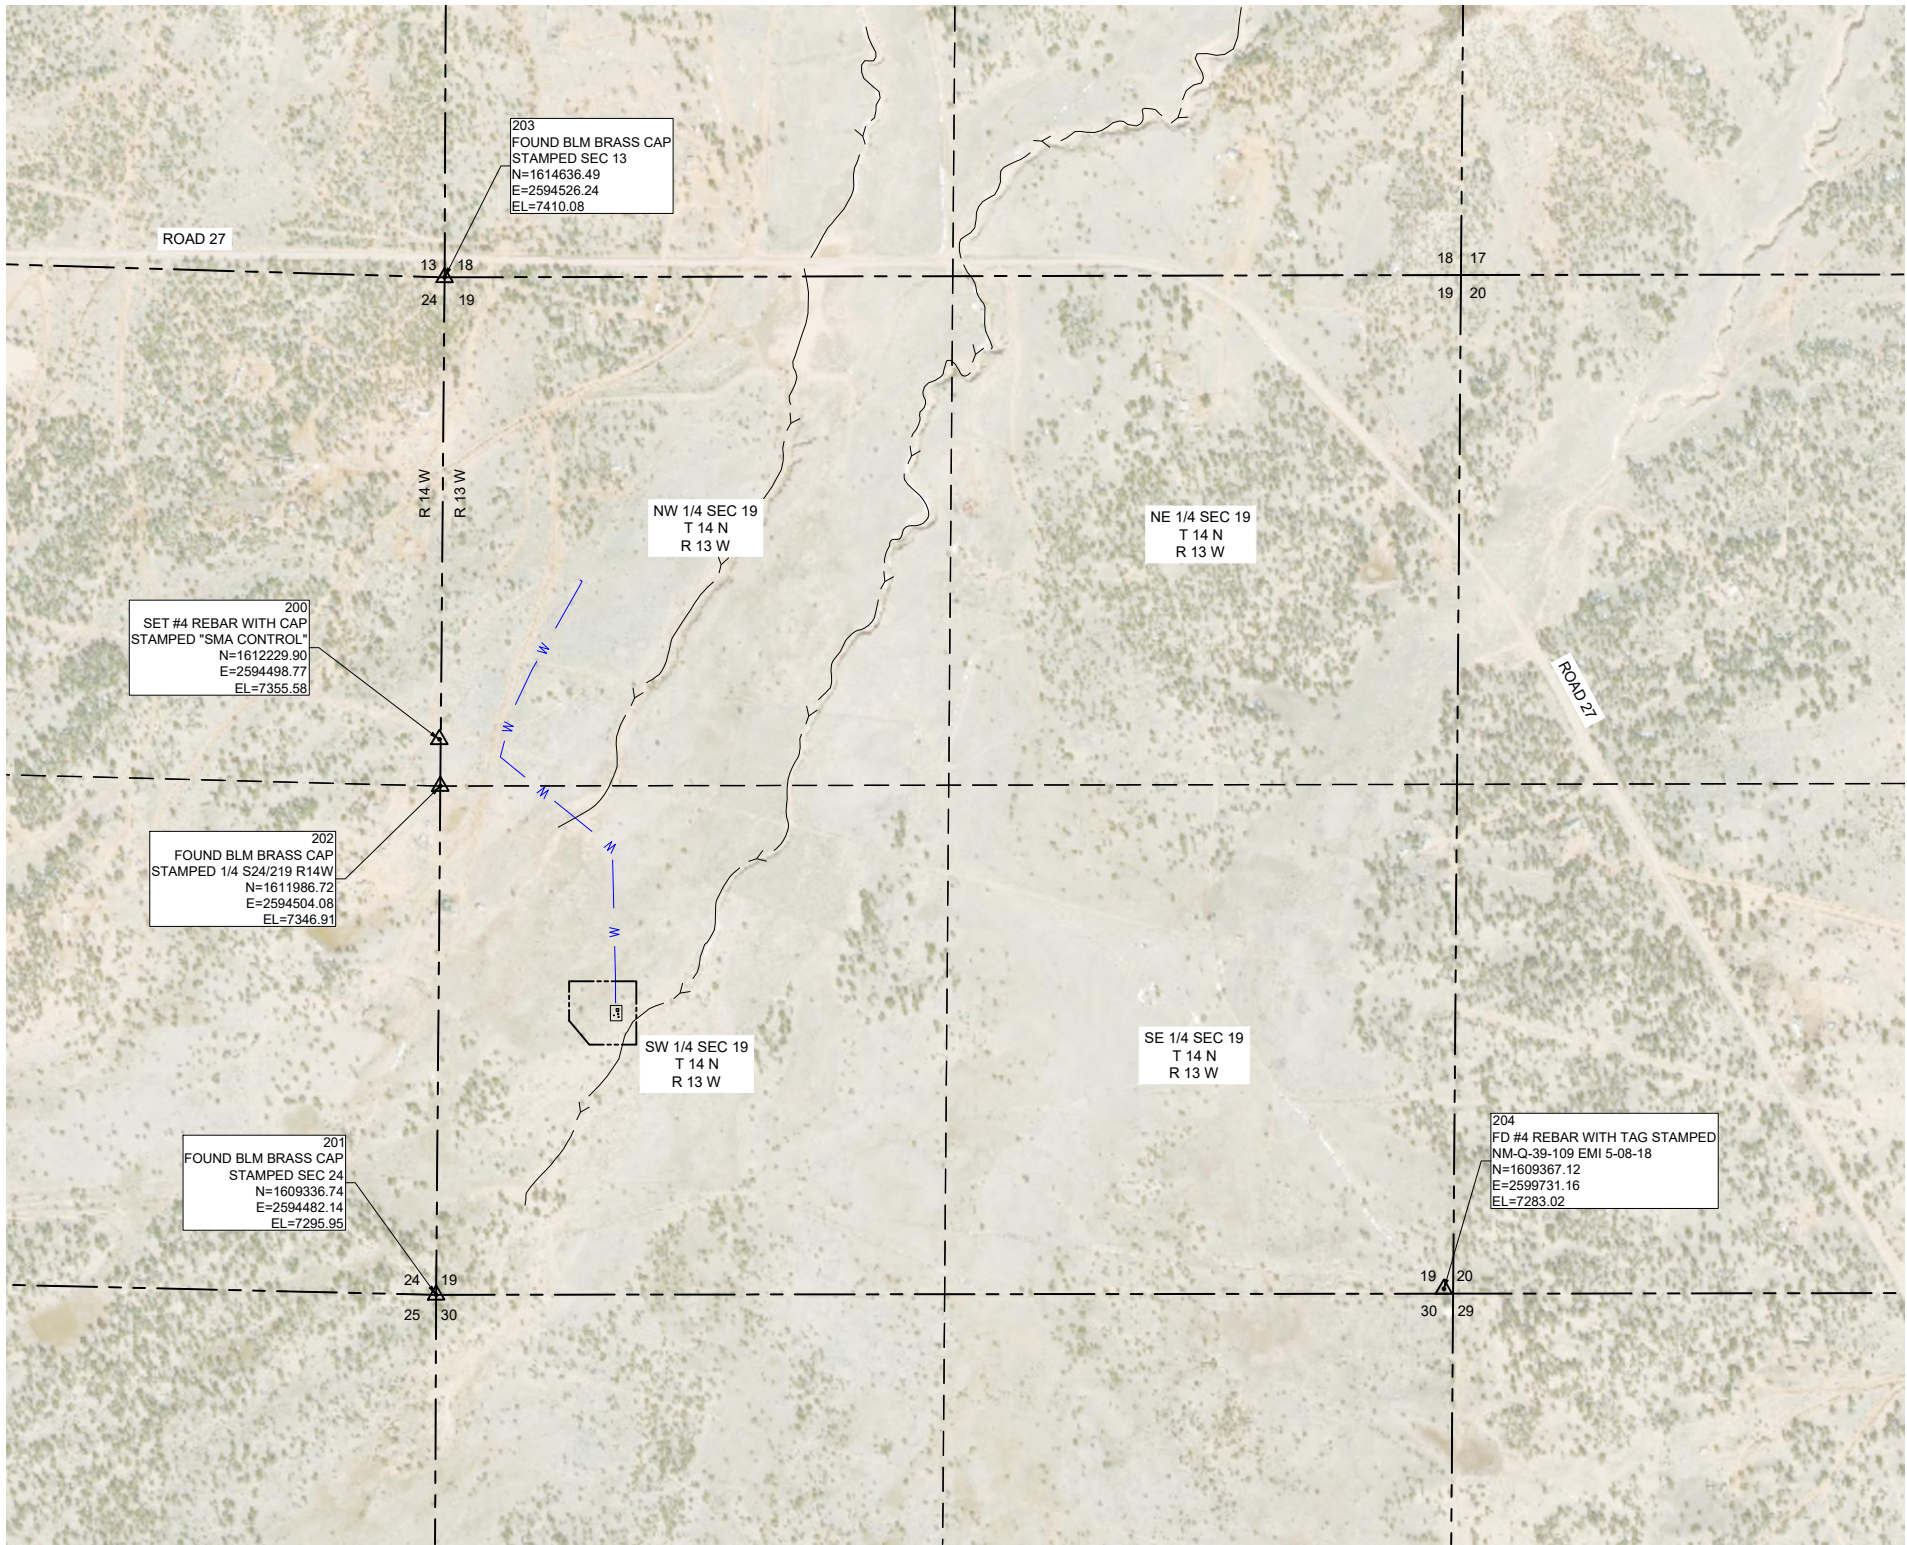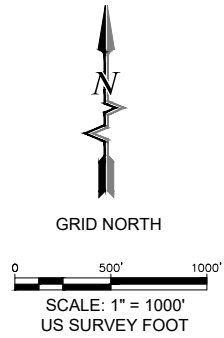

Point Table				
POINT #	NORTHING	EASTING	ELEVATION	DESCRIPTION
200	1612229.90	2594498.77	7355.58	SET #4 REBAR WITH CAP STAMPED "SMA CONTROL"
201	1609336.74	2594482.14	7295.95	FOUND BLM BRASS CAP STAMPED SEC 24
202	1611986.72	2594504.08	7346.91	FOUND BLM BRASS CAP STAMPED 1/4 S24/219 R14W
203	1614636.49	2594526.24	7410.08	FOUND BLM BRASS CAP STAMPED SEC 13
204	1609367.12	2599731.16	7283.02	FD #4 REBAR WITH TAG STAMPED NM-Q-39-109 EMI 5-08-18

PROJECT COORDINATE SYSTEM INFORMATION

COORDINATE SYSTEM
MODIFIED US STATE PLANE 1983
NEW MEXICO WEST ZONE
ALL DISTANCES ARE GROUND DISTANCES, UNITS ARE US SURVEY FEET
ALL COORDINATES ARE GROUND COORDINATES
GRID TO GROUND SCALE FACTOR= 1.0004123810
SCALED FROM: N35°25'49.27483" W108°15'53.98834" (N= 1612229.903 E= 2594498.769)
VERTICAL DATUM
NAVD 1988
GEOID 12B(CONUS) WAS UTILIZED TO ESTABLISH ORTHO HEIGHTS

METHODS
ALL CONTROL ON THIS PROJECT WAS OBSERVED AND SET ON JUNE 21-22, 2018. ALL POINTS WERE OBSERVED USING TRIMBLE R8 GPS RECEIVERS UTILIZING RTK GPS METHODS.

I, JAMES D. COMBS, NEW MEXICO PROFESSIONAL SURVEYOR NO. 23200, DO HEREBY CERTIFY THAT THIS CONTROL SURVEY REPORT WAS PREPARED BY ME OR UNDER MY DIRECT SUPERVISION BASED ON AN ACTUAL SURVEY ON THE GROUND AS DESCRIBED HEREIN; THAT I AM RESPONSIBLE FOR THIS SURVEY; AND THAT THE SURVEY AND REPORT MEETS THE MINIMUM STANDARDS FOR SURVEYING IN NEW MEXICO.

James David Combs
JAMES DAVID COMBS, N.M.P.S. 23200



10/11/18
DATE

THE NAVAJO NATION MCKINLEY COUNTY, NEW MEXICO

THOREAU BACA WELL CONNECTION
SURVEY CONTROL

SMA
SOUDER, MILLER & ASSOCIATES
Engineering • Environmental • Geomatics
Serving the Southwest & Rocky Mountains
5454 Venice Avenue NE, Suite D
Albuquerque, NM 87113
Phone (505) 299-0942 Toll-Free (877) 299-0942 Fax (505) 293-3400
www.soudermiller.com

Rev #	Date	Description	By	Chkd

THIS DRAWING IS INCOMPLETE AND NOT TO BE USED FOR CONSTRUCTION UNLESS IT IS STAMPED, SIGNED AND DATED



Designed TTT	Drawn AAV	Checked JDC
-----------------	--------------	----------------

Date: **March 2021**
Scale: Horiz: 1" = 1000'
Vert: N/A
Project No: 6922883
Sheet: **C-1**

NOTE:
THIS SHEET CONTAINS WORK IN THE VICINITY OF A
"CULTURALLY SENSITIVE AREA". ENGINEER MUST BE NOTIFIED
AT LEAST FIVE (5) WORKING DAYS PRIOR TO ANY GROUND
DISTURBING ACTIVITIES WITHIN 50 FEET OF SENSITIVE AREA.

SITE SPECIFIC REQUIREMENTS INCLUDE:

- TEMPORARY FENCING OF SITE BOUNDARIES BY OWNER-PROVIDED ARCHAEOLOGIST
- NO WORK WITHIN 50 FT. OF CULTURALLY SENSITIVE AREA WITHOUT TEMPORARY FENCING IN PLACE BY ARCHAEOLOGIST
- ON-SITE MONITORING BY OWNER-PROVIDED ARCHAEOLOGIST
- NO GROUND-DISTURBING WORK WITHIN SENSITIVE AREA WITHOUT ARCHAEOLOGIST ONSITE

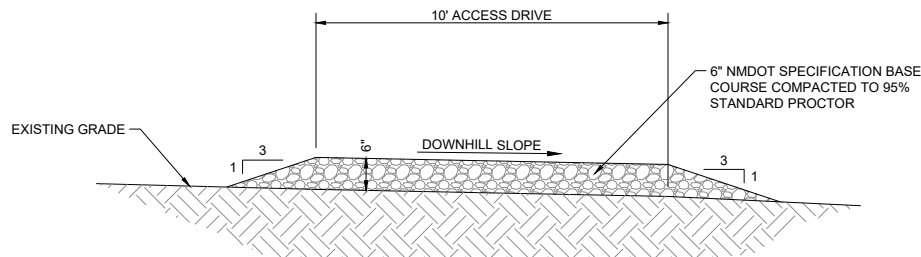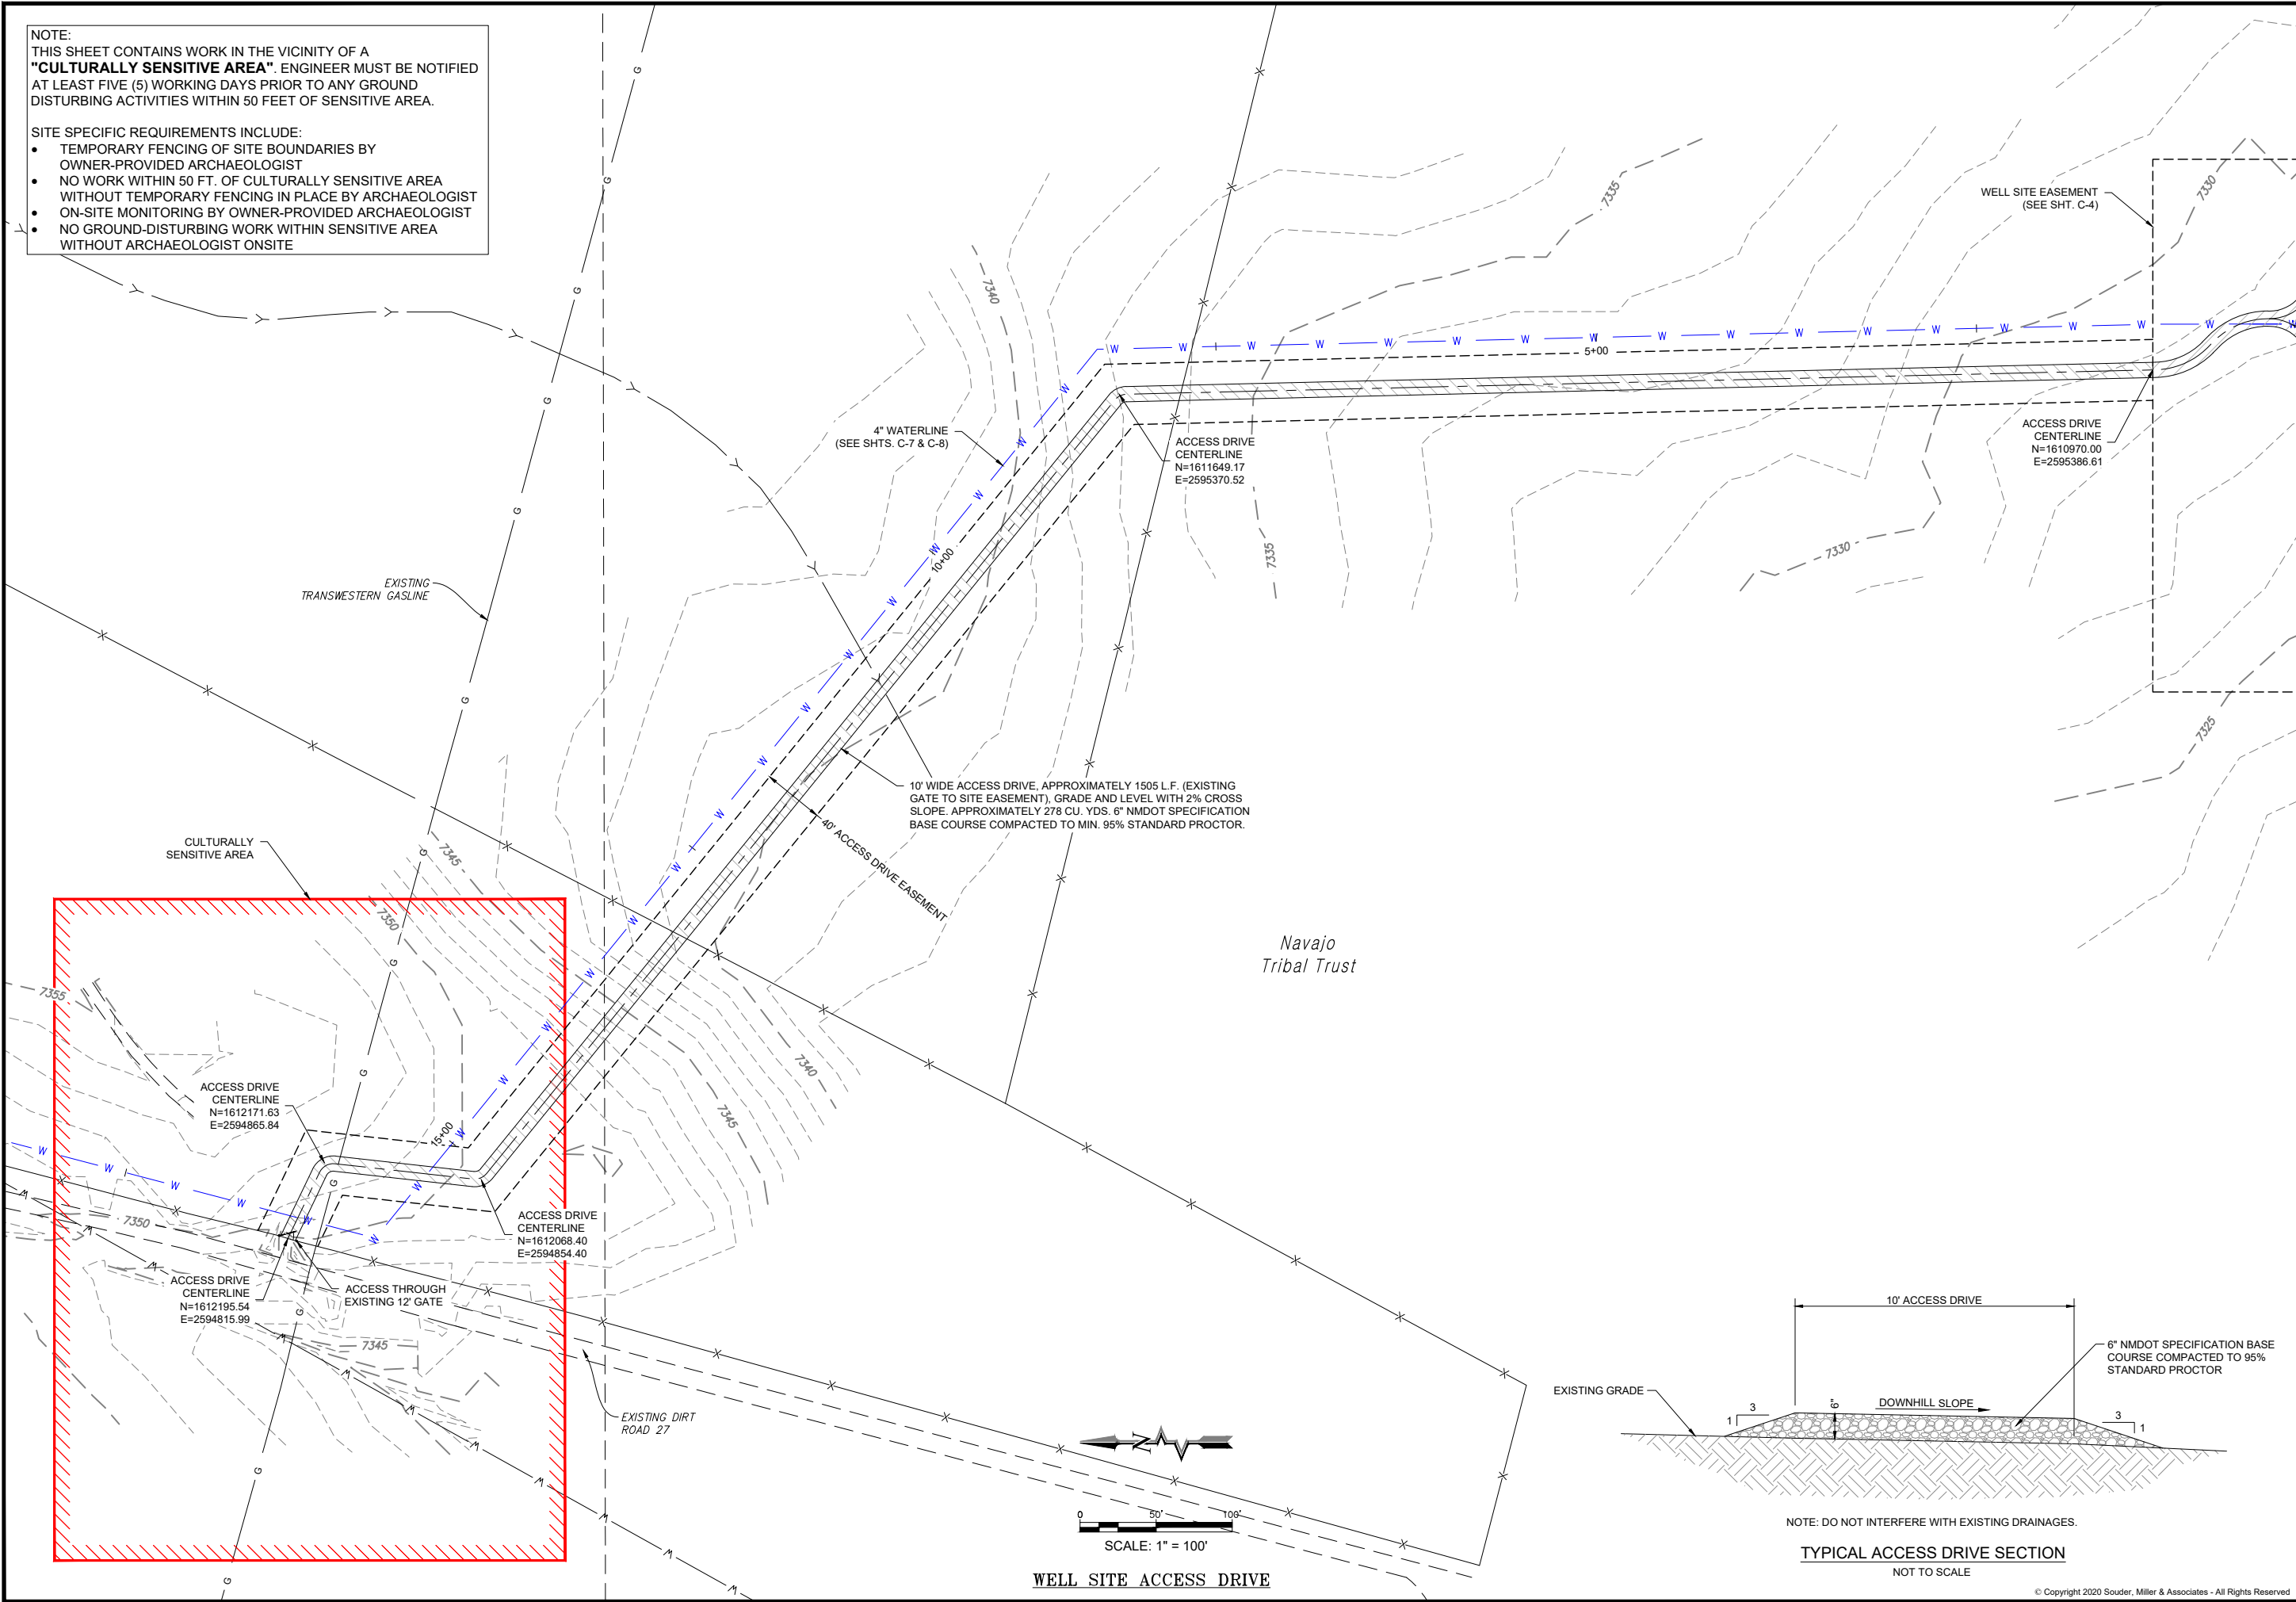

NOTE: DO NOT INTERFERE WITH EXISTING DRAINAGES.

TYPICAL ACCESS DRIVE SECTION

NOT TO SCALE

SOUDER, MILLER & ASSOCIATES
Engineering • Environmental • Geomatics
Serving the Southwest & Rocky Mountains
5454 Venice Avenue NE, Suite D
Albuquerque, NM 87113
Phone (505) 299-0942 Toll-Free (877) 299-0942 Fax (505) 293-3430
www.soudermiller.com

THE NAVAJO NATION
McKINLEY COUNTY, NEW MEXICO
THOREAU BACA WELL CONNECTION
SECTION 19, T. 14 N., R. 13 W.
WELL SITE ACCESS DRIVE

FINAL DESIGN
FOR REVIEW

THIS DRAWING IS INCOMPLETE
AND NOT TO BE USED FOR
CONSTRUCTION UNLESS IT IS
STAMPED, SIGNED AND DATED

Designed TTT Drawn AAV Checked JMG


Date: March 2021

Scale: Horiz: 1" = 100'
Vert: N/A

Project No: 6922883

Sheet:

C-3

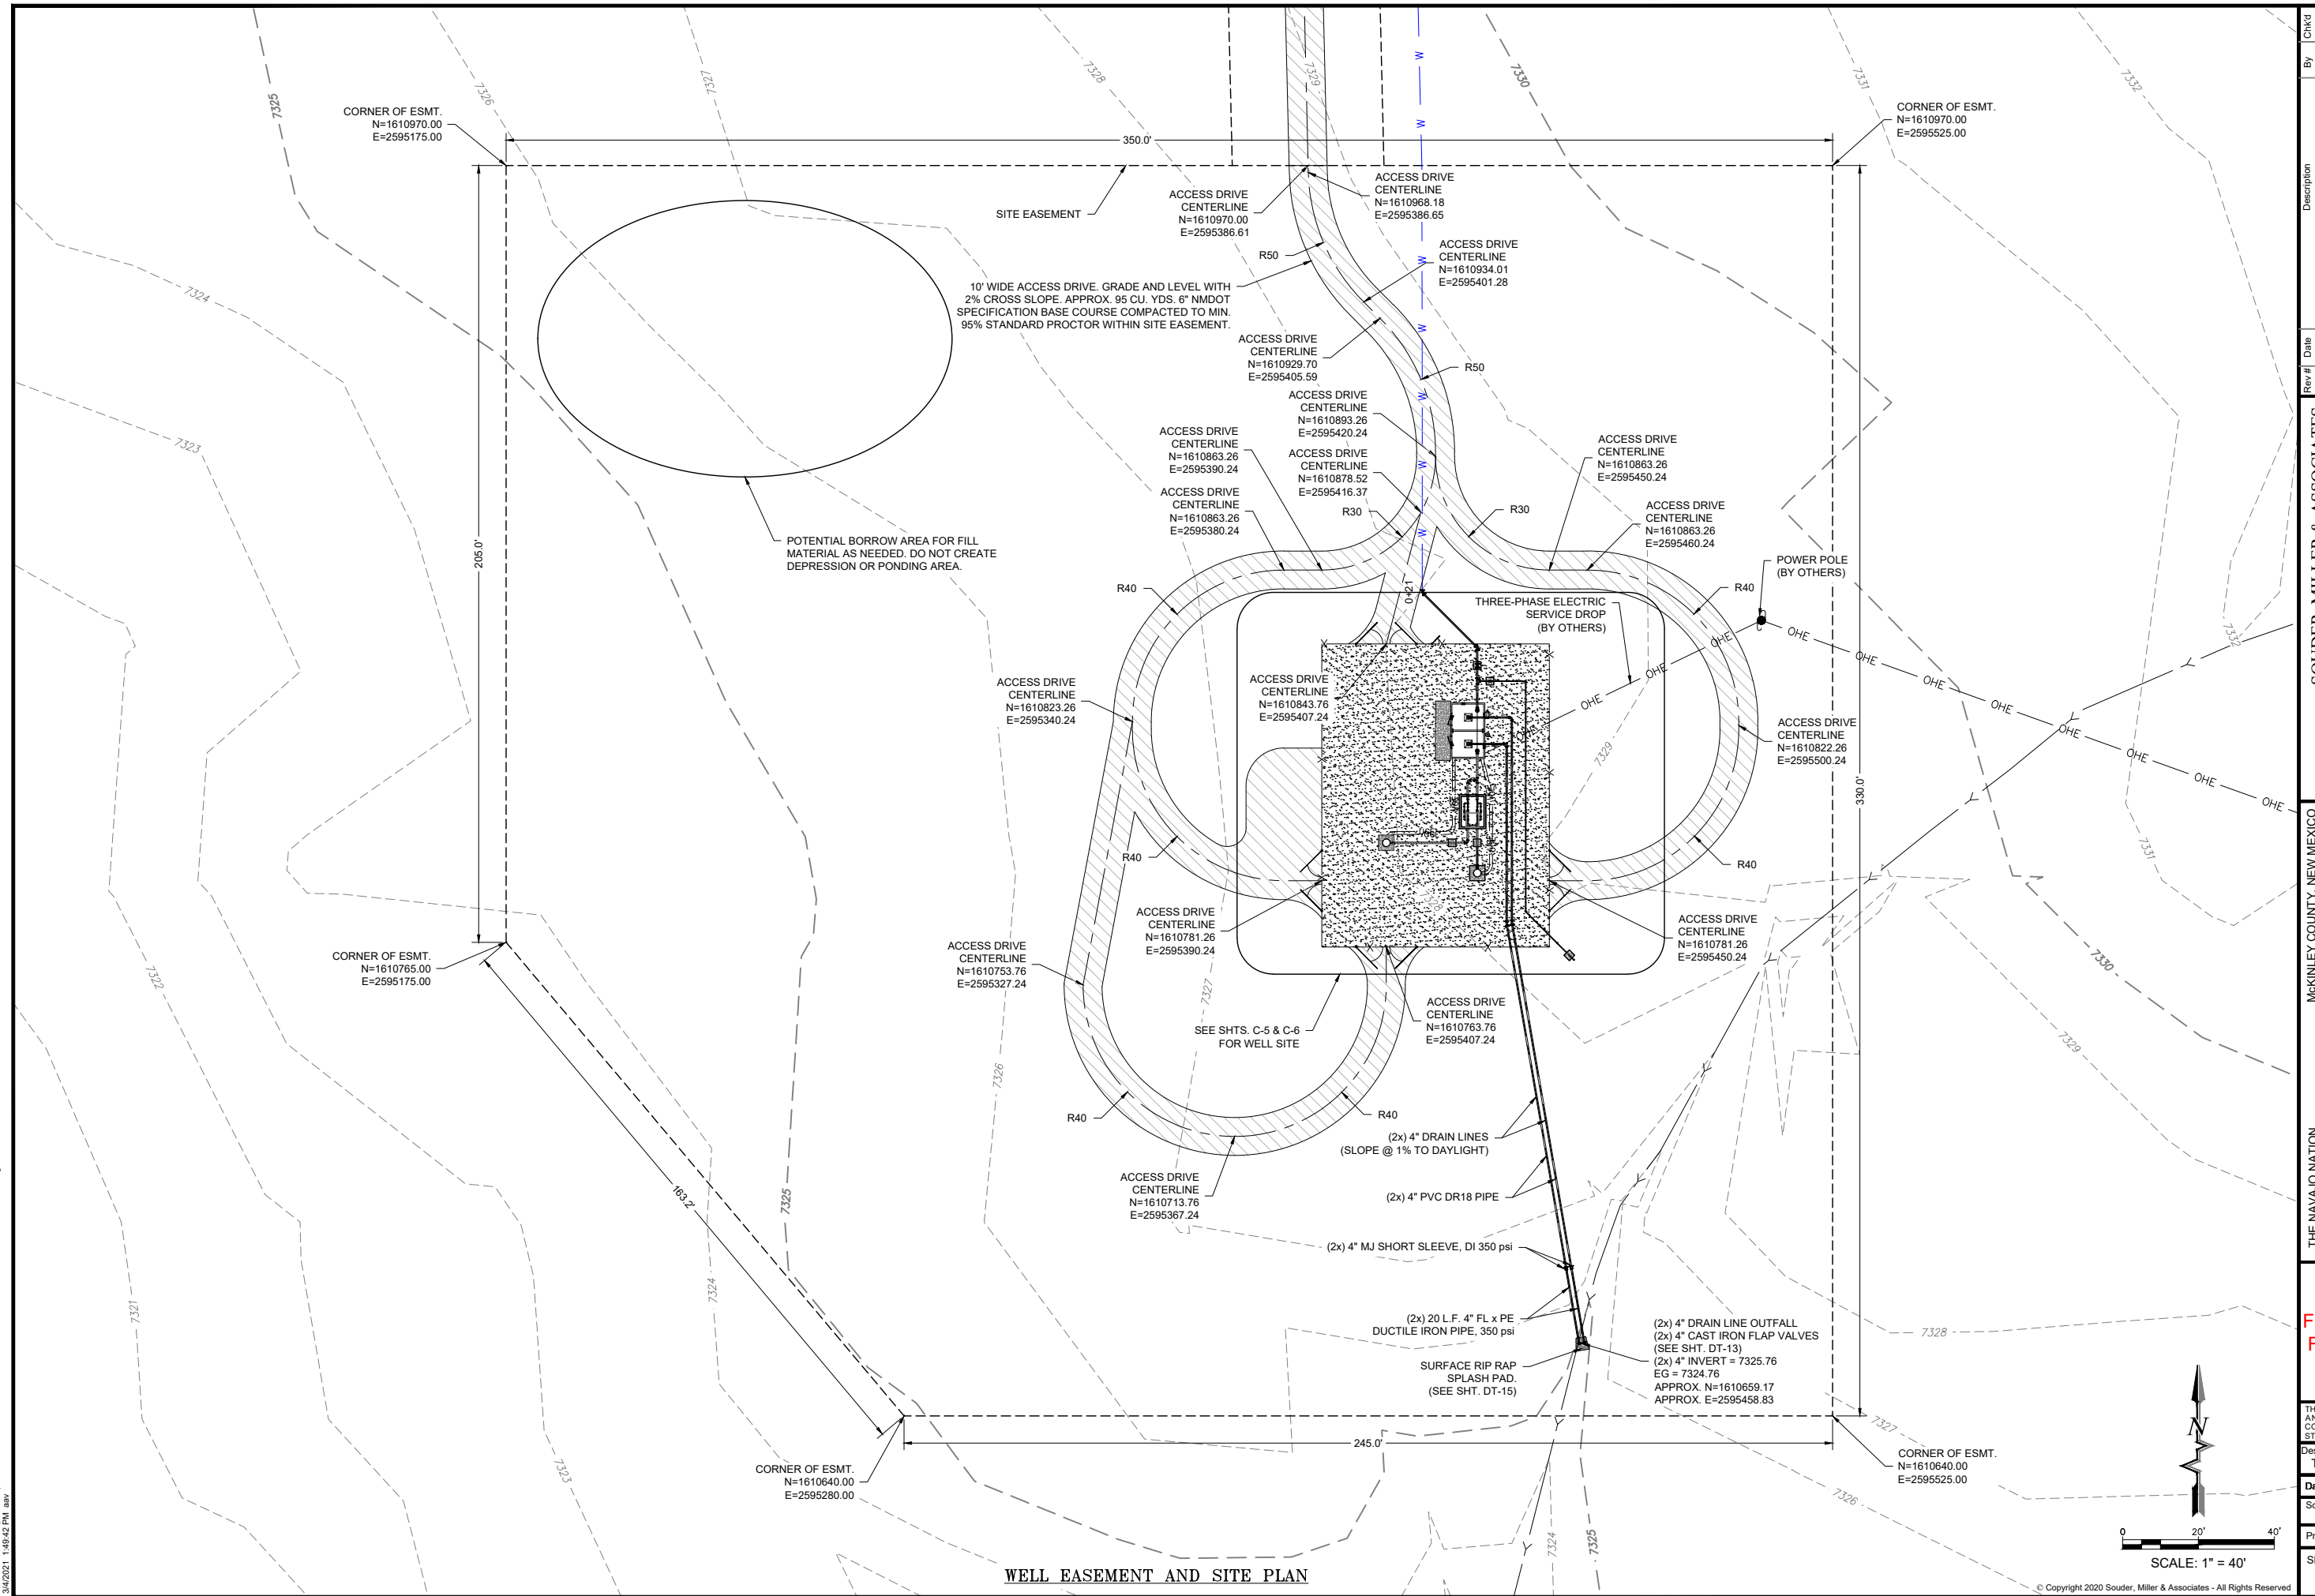[illegible]

SMA
Engineering • Environmental • Geomatics
Serving the Southwest & Rocky Mountains
5454 Venice Avenue NE, Suite D
Albuquerque, NM 87113
Phone (505) 299-0942 Toll-Free (877) 299-0942 Fax (505) 293-3430
www.soudermiller.com

THE MAYAGUAY DIVISION

THOREAU BACA WELL CONNECTION
SECTION 19, T. 14 N., R. 13 W.
WELL EASEMENT AND SITE PLAN

WATERWAY COUNTY HEALTH DEPARTMENT

FINAL DESIGN
FOR REVIEW

THIS DRAWING IS INCOMPLETE
AND NOT TO BE USED FOR
CONSTRUCTION UNLESS IT IS
STAMPED, SIGNED AND DATED

Designed TTT	Drawn AAV	Checked JMG
-----------------	--------------	----------------


ate: March 2021

Scale: Horiz: 1" = 40'
Vert: N/A

Project No: 6922883

Sheet: C-4

P:\6-Baca-Prewitt (6922883)\Baca Thoreau Well Connection\CAD\DWG\6922883-Thoreau Well Conn-SITES.dwg
3/4/2021 1:49:42 PM aav

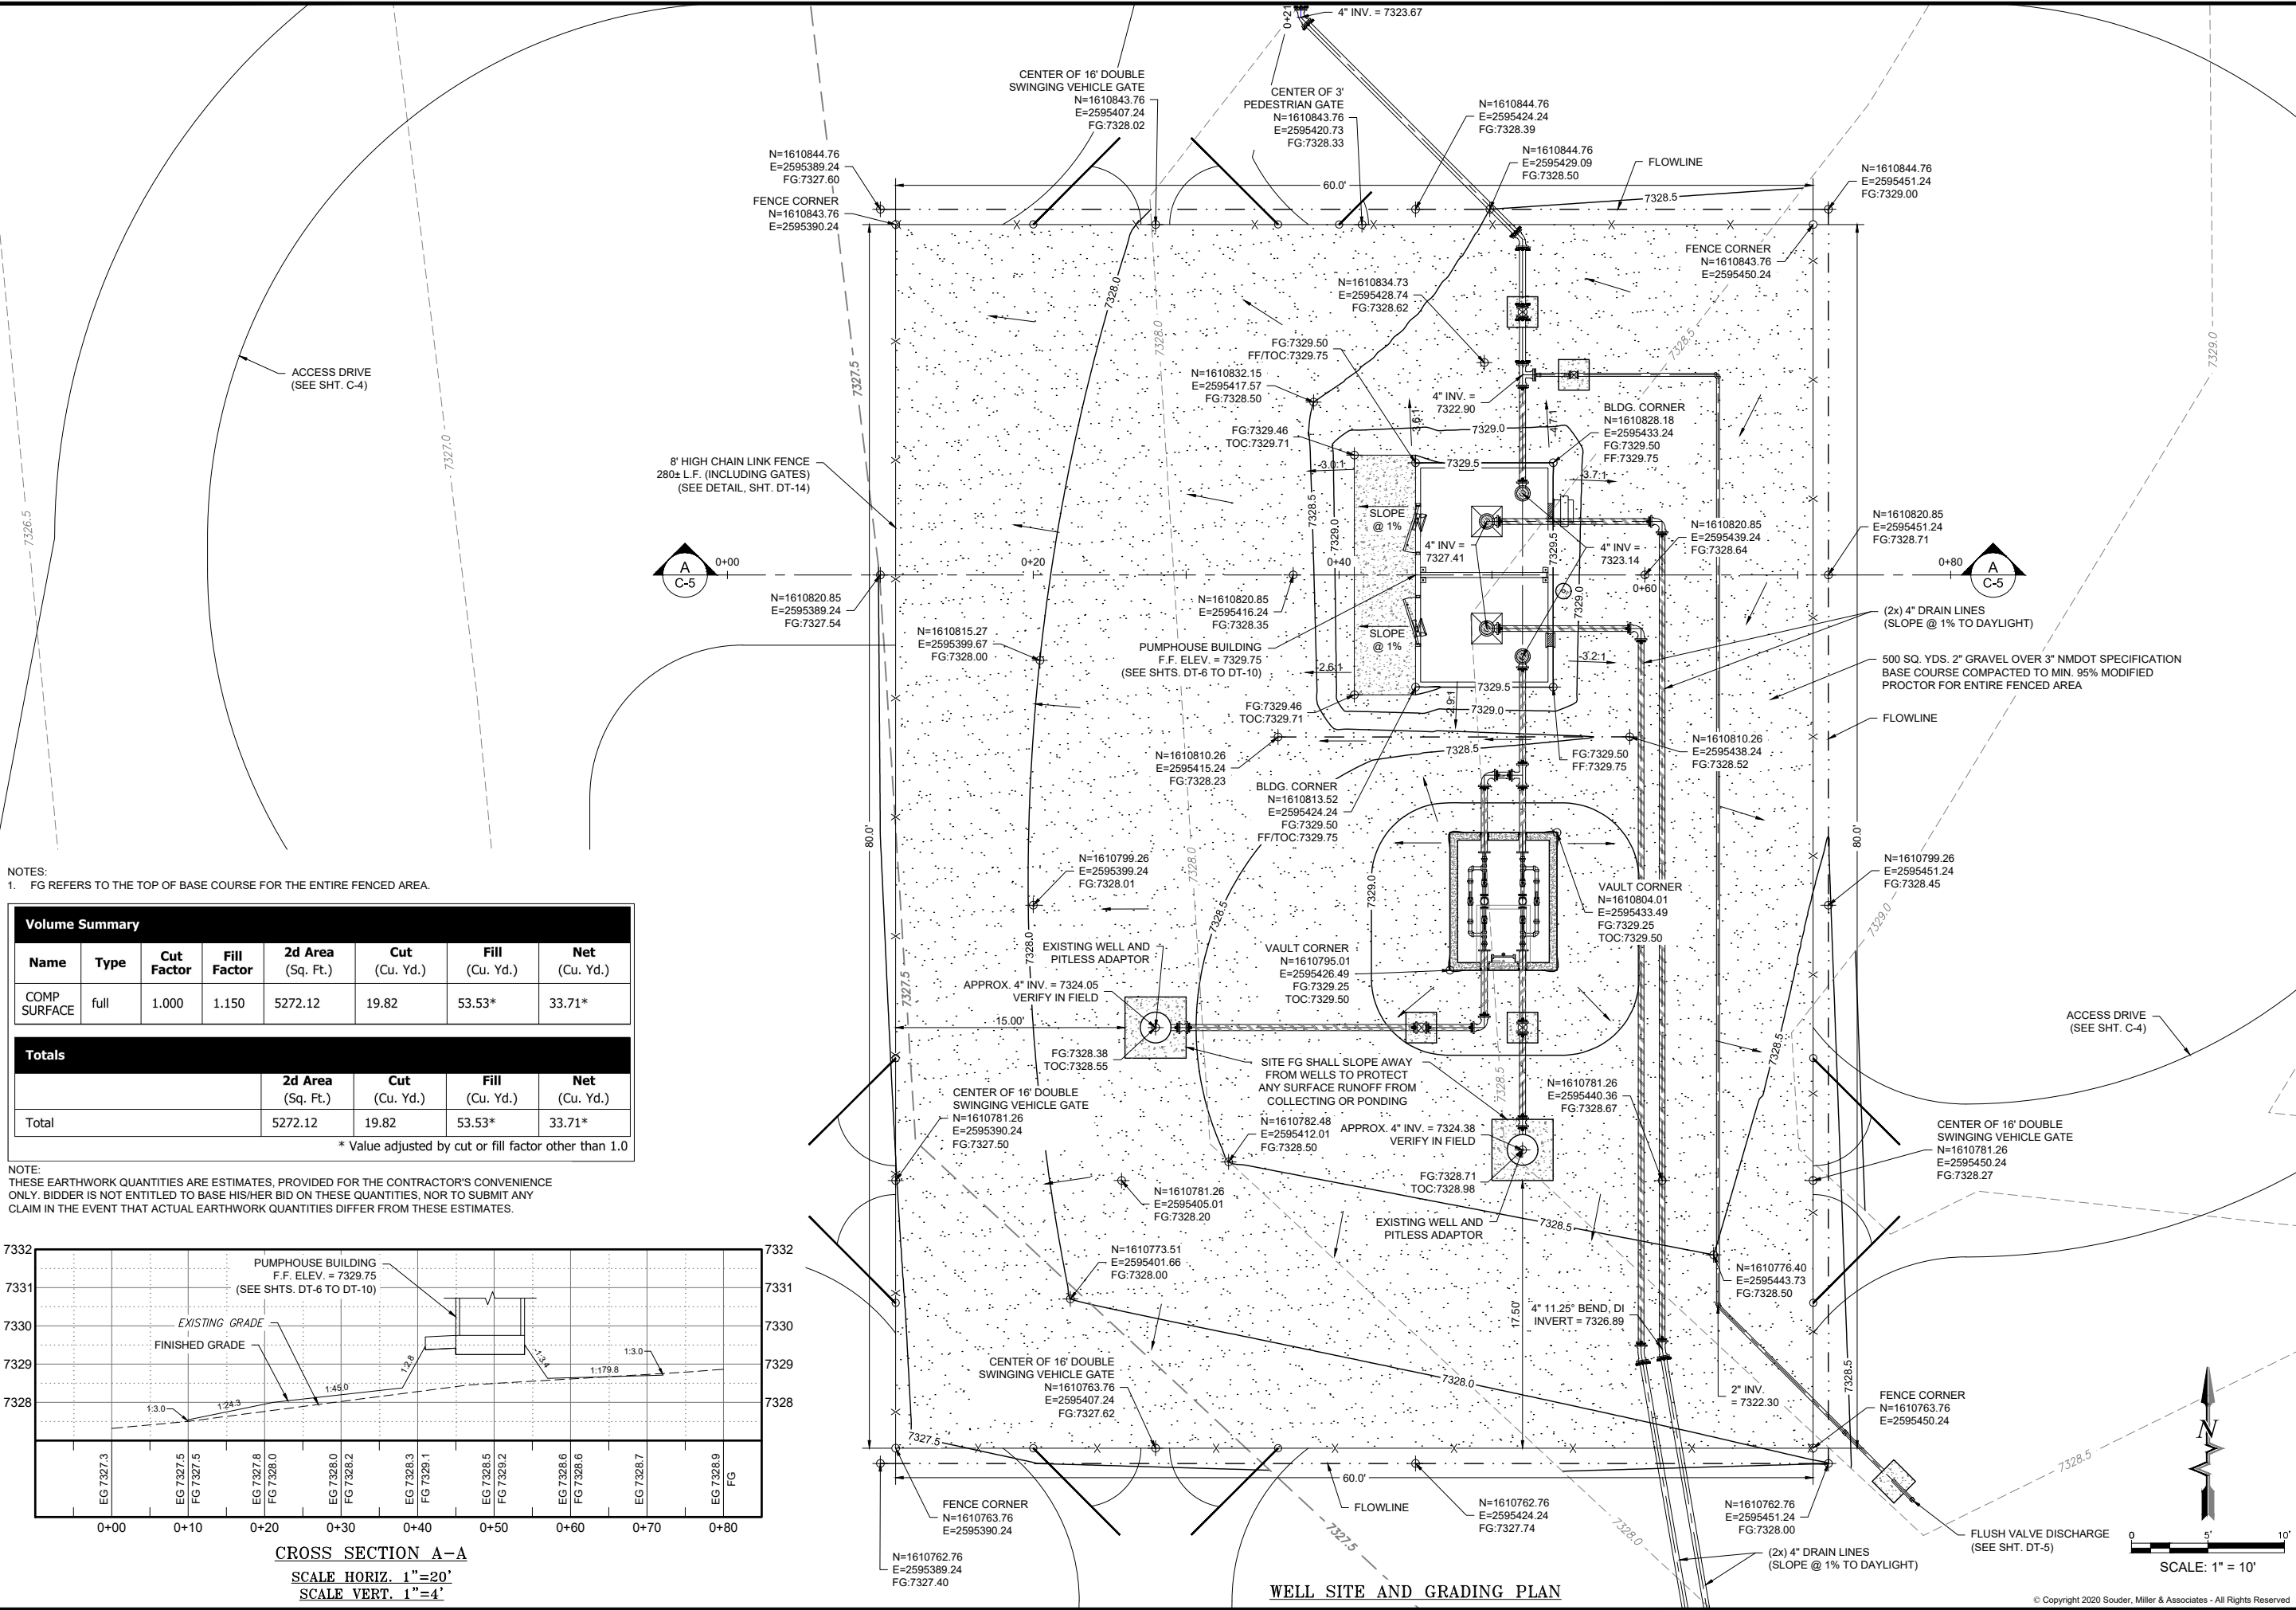


NOTES:
1. FG REFERS TO THE TOP OF BASE COURSE FOR THE ENTIRE FENCED AREA.

Volume Summary							
Name	Type	Cut Factor	Fill Factor	2d Area (Sq. Ft.)	Cut (Cu. Yd.)	Fill (Cu. Yd.)	Net (Cu. Yd.)
COMP SURFACE	full	1.000	1.150	5272.12	19.82	53.53*	33.71*
Totals							
				2d Area (Sq. Ft.)	Cut (Cu. Yd.)	Fill (Cu. Yd.)	Net (Cu. Yd.)
Total				5272.12	19.82	53.53*	33.71*

* Value adjusted by cut or fill factor other than 1.0

NOTE:
THESE EARTHWORK QUANTITIES ARE ESTIMATES, PROVIDED FOR THE CONTRACTOR'S CONVENIENCE ONLY. BIDDER IS NOT ENTITLED TO BASE HIS/HER BID ON THESE QUANTITIES, NOR TO SUBMIT ANY CLAIM IN THE EVENT THAT ACTUAL EARTHWORK QUANTITIES DIFFER FROM THESE ESTIMATES.

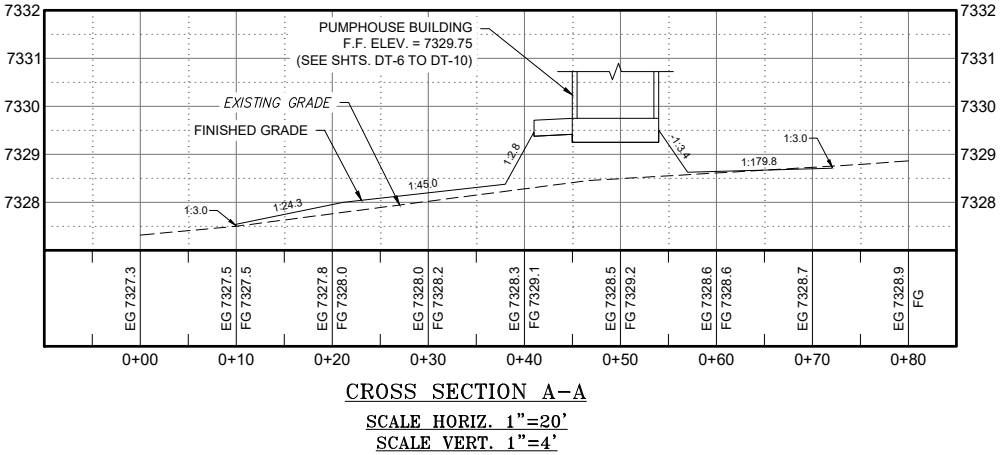

By: []
Date: []
Description: []
Rev # []

SOUDER, MILLER & ASSOCIATES
Engineering • Environmental • Geomatics
Serving the Southwest & Rocky Mountains
5454 Venice Avenue NE, Suite D
Albuquerque, NM 87113
Phone (505) 299-0942 Toll-Free (877) 299-0942 Fax (505) 293-3400
www.soudermiller.com

McKinley County, New Mexico

THOREAU BACA WELL CONNECTION
SECTION 19, T. 14 N., R. 13 W.
WELL SITE AND GRADING PLAN

FINAL DESIGN
FOR REVIEW

THIS DRAWING IS INCOMPLETE AND NOT TO BE USED FOR CONSTRUCTION UNLESS IT IS STAMPED, SIGNED AND DATED

Designed TTT
Drawn AAV
Checked JMG

Date: March 2021

Scale: Horiz: AS SHOWN
Vert: 1" = 4'



Project No: 6922883

Sheet: C-5

P:\BACA-Previtt (6922883)\BACA Thoreau Well Connection\CAD\DWG\6922883-Thoreau Well Com-SITES.dwg
3/4/2021 1:45:52 PM gaw

KEYED NOTES - THOREAU WELL SITE	
Item No.	Description
1	4" MJ x MJ GATE VALVE (SEE DETAIL DT-2) 350 psi
2	4" PVC DR18 C900 PIPE
3	4" DUCTILE IRON PIPE 350 psi
4	4" MJ x MJ TEE, D.I. 350 psi
5	4" MJ x 2" THREADED PLUG, D.I. 350 psi
6	4" MJ x MJ SHORT SLEEVE, D.I. 350 psi
7	4" 90° BEND, D.I. 350 psi
8	4" 45° BEND, D.I. 350 psi
9	4" 11.25° BEND, D.I. 350 psi
10	2" FLUSH VALVE ASSEMBLY (SEE DETAIL DT-5)
11	2" G.I. PIPE, STANDARD WALL, NPT, TAPE COATED BELOW GRADE
12	2" G.I. 90° BEND, NPT, 300 psi
13	2" G.I. 45° BEND, NPT, 300 psi
14	UNDERGROUND ELECTRIC
15	METER VAULT (SEE DETAIL, #####)

- NOTES:**
1. NO HIGH SPOTS PERMITTED ON SITE PIPING.
 2. ALL MATERIALS, FITTINGS AND APPURTENANCES SHALL BE RATED TO AT LEAST 235 psi, UNLESS OTHERWISE NOTED.
 3. ALL VALVES SHALL BE LOCATED AT LEAST 5' FROM EDGES OF FOUNDATIONS.
 4. ALL BURIED NON-STAINLESS STEEL PIPE AND FITTINGS SHALL BE COLD-APPLIED TAPE-WRAPPED, PER SPECIFICATIONS.
 5. ALL BURIED DUCTILE IRON FITTINGS SHALL BE MJ. ALL BURIED DUCTILE IRON PIPES SHALL BE SOLID PIECES. NO DUCTILE IRON PIPE JOINTS ALLOWED.
 6. ALL PRESSURE BEARING PIPES WITHIN SITE SHALL BE FULLY RESTRAINED. REFER TO DETAIL, SHEET DT-1.
 7. FIELD LOCATE CONDUITS PER REVIEW WITH ELECTRICIAN.

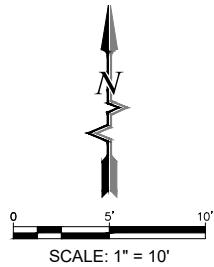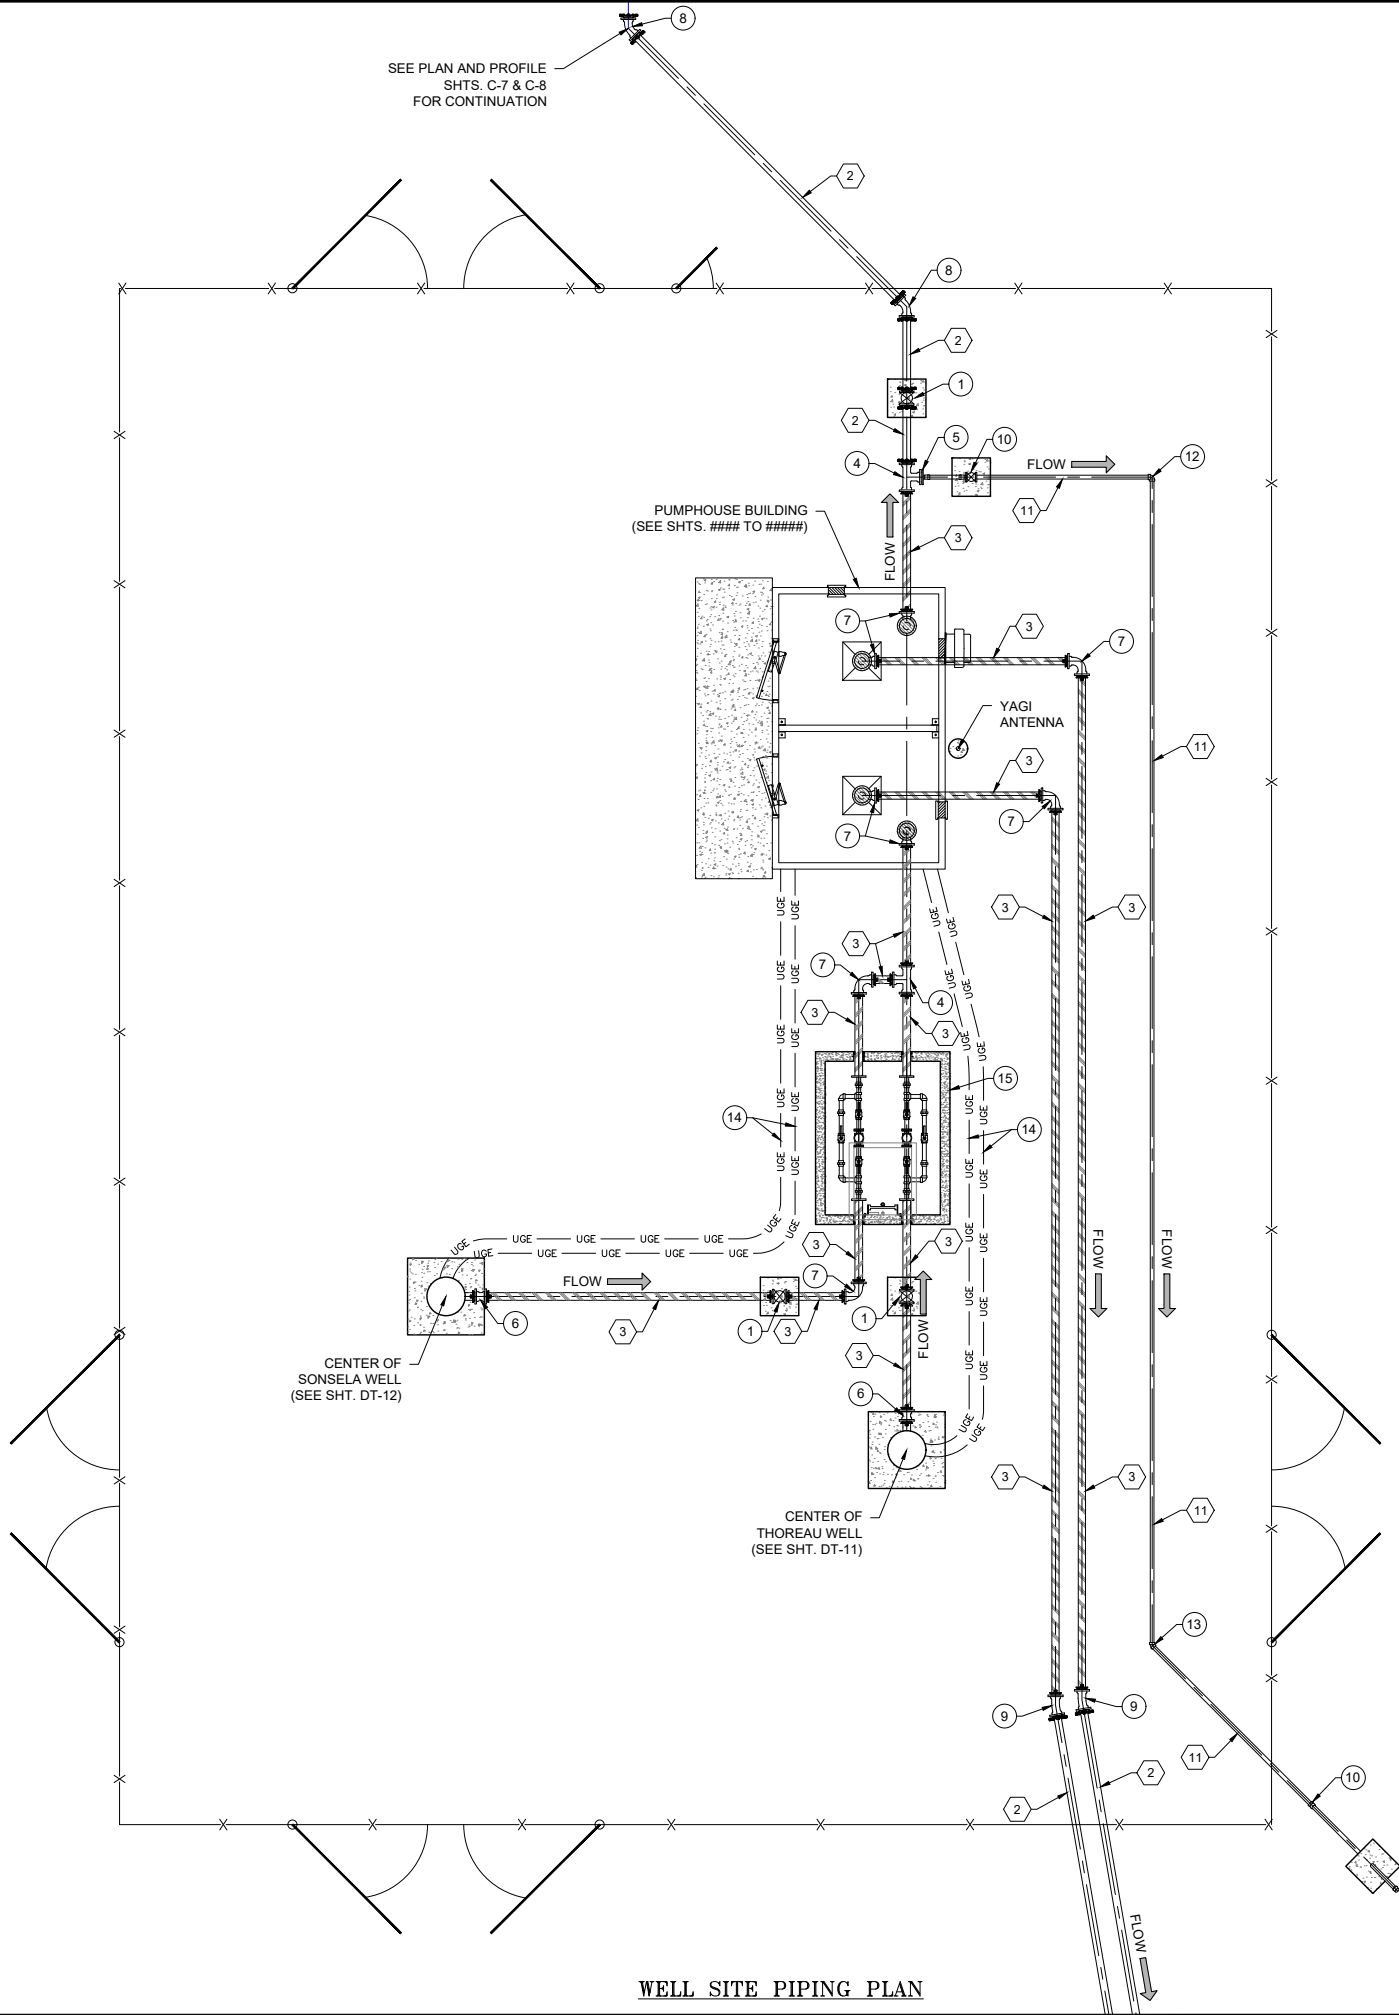

Rev #	Date	Description	By	Chkd

SOUDER, MILLER & ASSOCIATES
Engineering • Environmental • Geomatics
Serving the Southwest & Rocky Mountains
5454 Venice Avenue NE, Suite D
Albuquerque, NM 87113
Phone (505) 299-0942 Toll-Free (877) 299-0942 Fax (505) 293-3400
www.soudermiller.com

THE NAVAJO NATION MCKINLEY COUNTY, NEW MEXICO

THOREAU BACA WELL CONNECTION
SECTION 19, T. 14 N., R. 13 W.
WELL SITE PIPING PLAN

**FINAL DESIGN
FOR REVIEW**

THIS DRAWING IS INCOMPLETE
AND NOT TO BE USED FOR
CONSTRUCTION UNLESS IT IS
STAMPED, SIGNED AND DATED

Designed TTT	Drawn AAV	Checked JMG
-----------------	--------------	----------------


Date: **March 2021**

Scale: Horiz: 1" = 10'
Vert: N/A

Project No: 6922883

Sheet: **C-6**


P:\BACA-Prewitt (6022883)\BACA Thoreau Well Connection\CAD\DWG\WFG - Thoreau Well Connection - (1) - (1).dwg
3/4/2021 1:50:45 PM aw

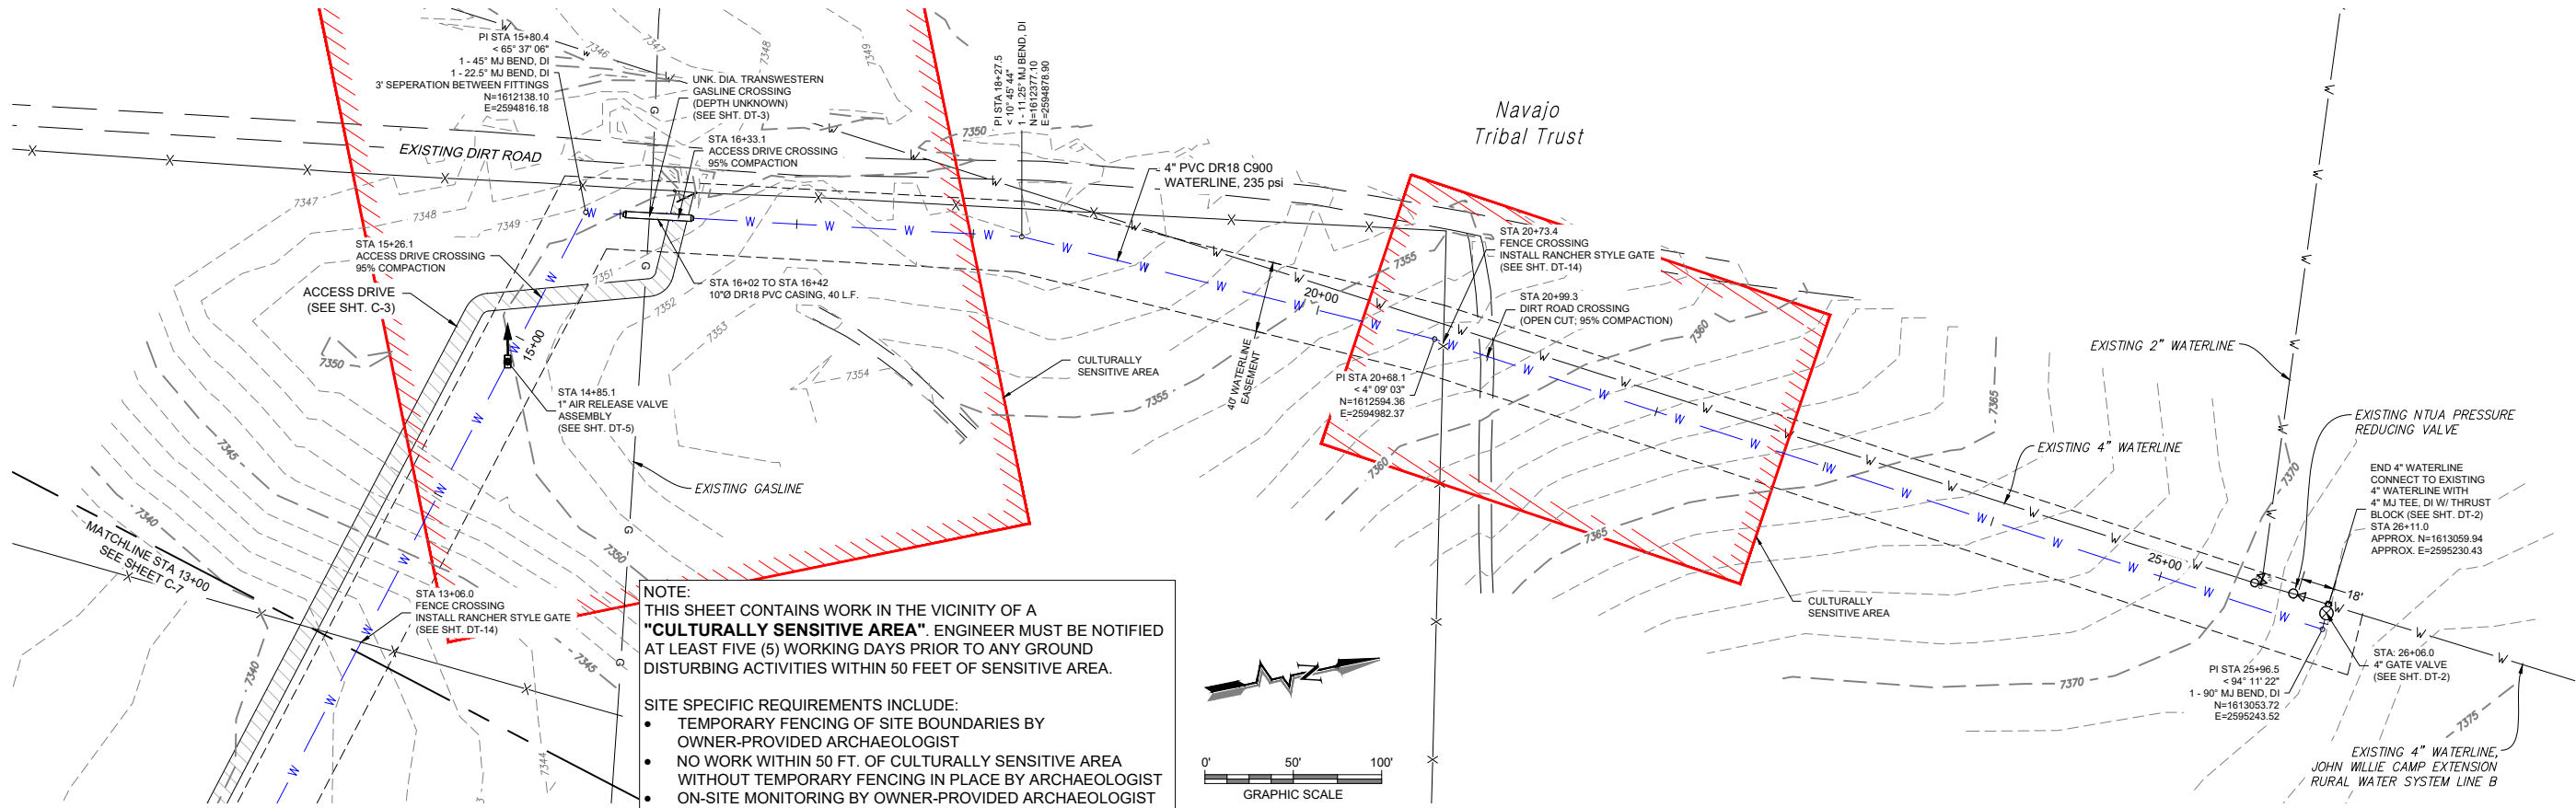


NOTE: THIS SHEET CONTAINS WORK IN THE VICINITY OF A "CULTURALLY SENSITIVE AREA". ENGINEER MUST BE NOTIFIED AT LEAST FIVE (5) WORKING DAYS PRIOR TO ANY GROUND DISTURBING ACTIVITIES WITHIN 50 FEET OF SENSITIVE AREA.

SITE SPECIFIC REQUIREMENTS INCLUDE:


- TEMPORARY FENCING OF SITE BOUNDARIES BY OWNER-PROVIDED ARCHAEOLOGIST
- NO WORK WITHIN 50 FT. OF CULTURALLY SENSITIVE AREA WITHOUT TEMPORARY FENCING IN PLACE BY ARCHAEOLOGIST
- ON-SITE MONITORING BY OWNER-PROVIDED ARCHAEOLOGIST
- NO GROUND-DISTURBING WORK WITHIN SENSITIVE AREA WITHOUT ARCHAEOLOGIST ONSITE

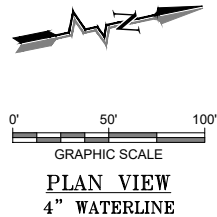

PLAN VIEW
4" WATERLINE

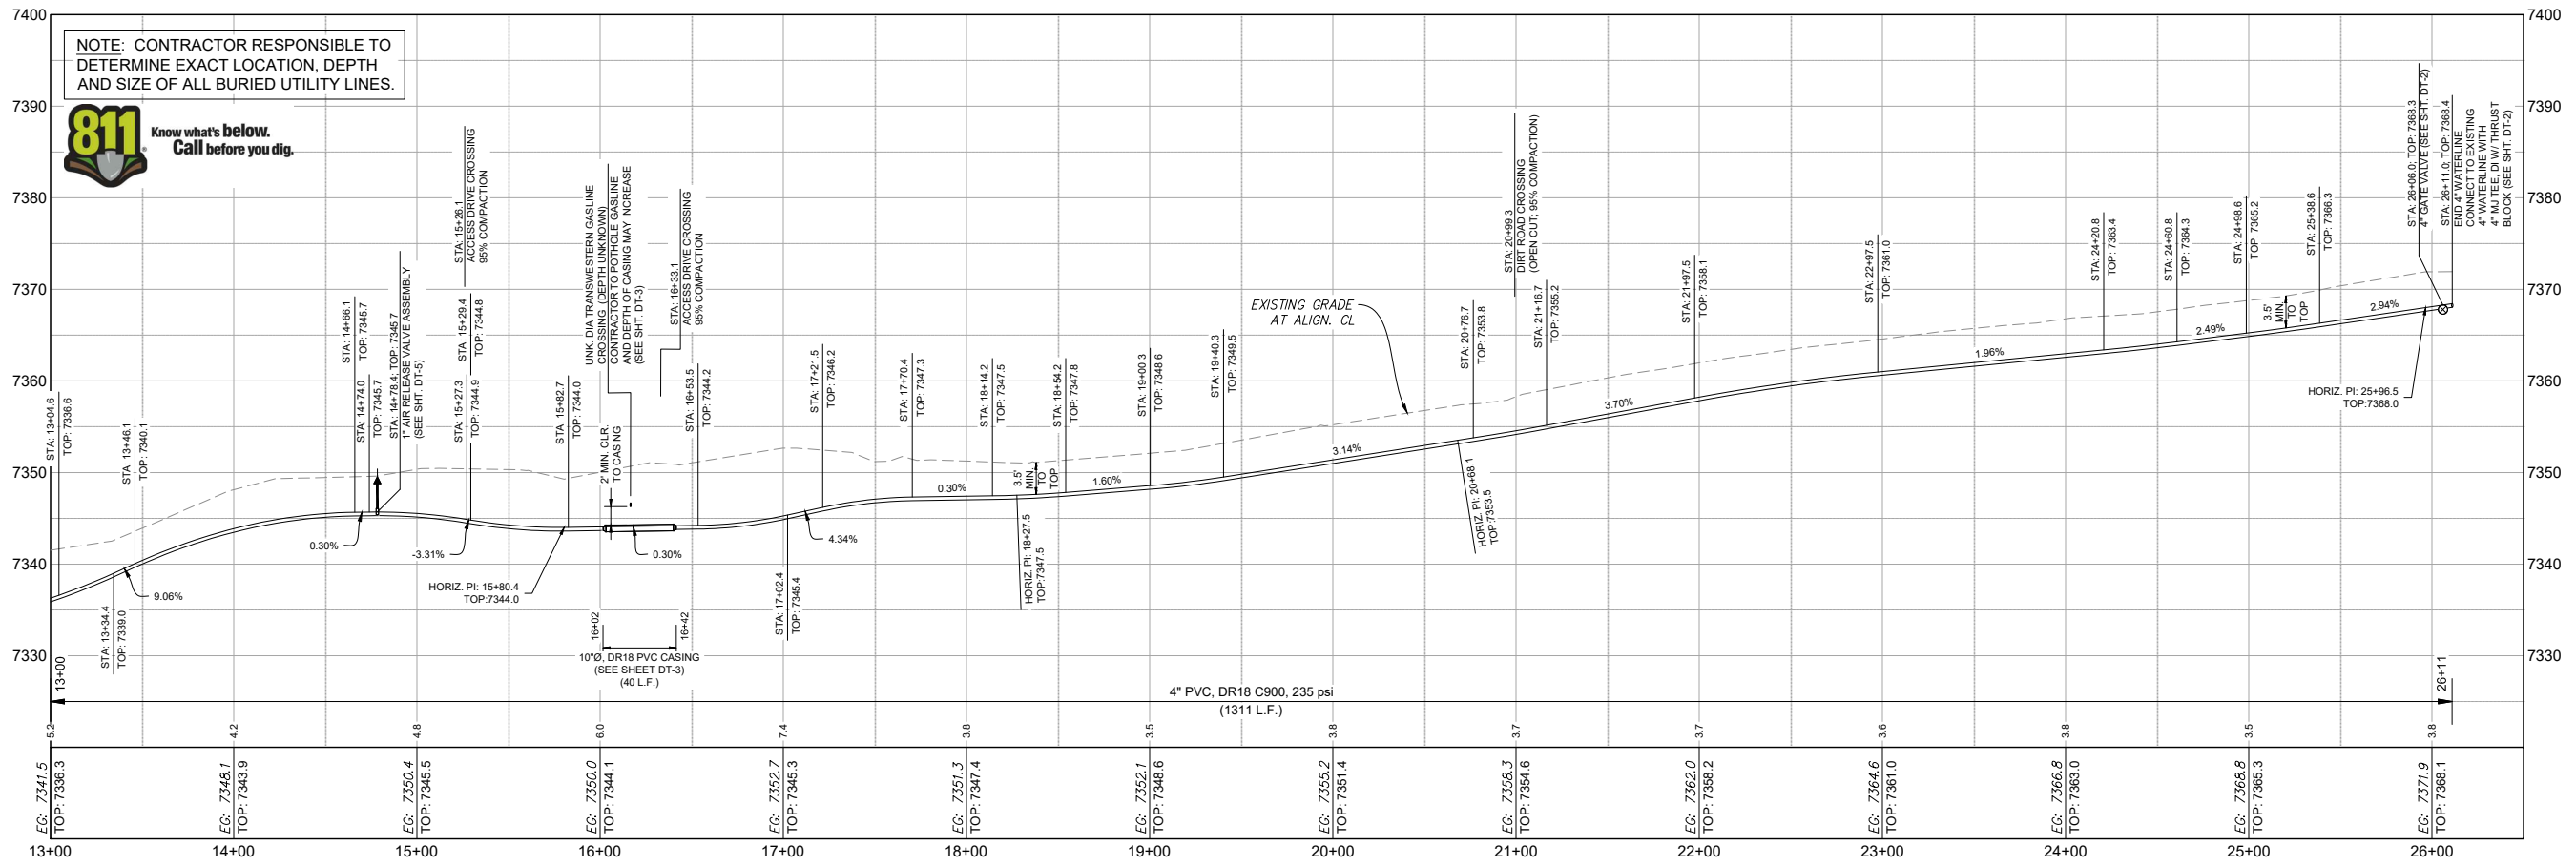


PROFILE VIEW
4" WATERLINE

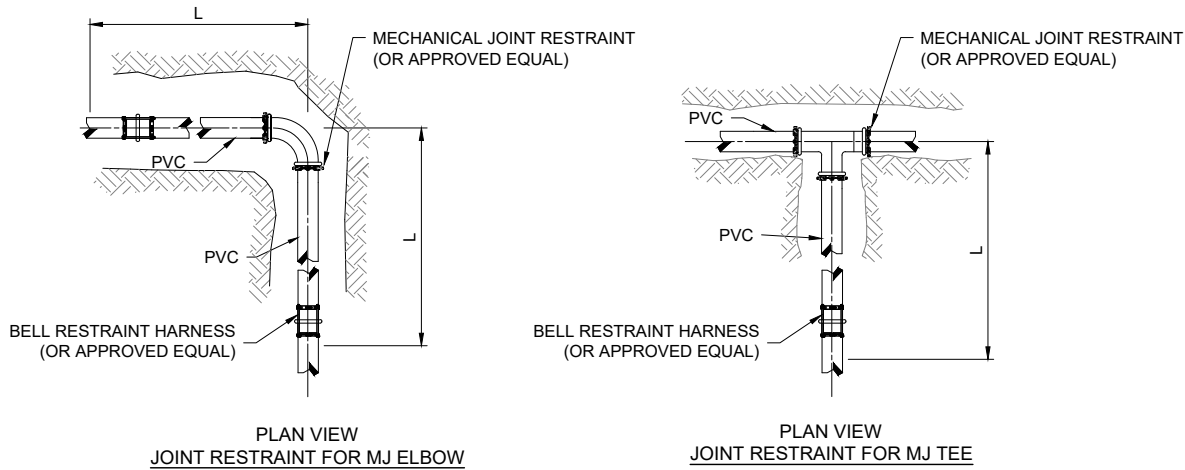


Minimum Required Restraint Lengths (L) for Individual Fittings

Fitting	Pipe Size	Pipe DR	Test Pressure (psi)	Design Restraint Length (ft)
Isolation Valve/ Dead End	4	18	235	65
From End of Casing	4	18	235	30
Horizontal Bend or Sweep				
90°	4	18	235	30
45°	4	18	235	20
22.5°	4	18	235	20
11.25°	4	18	235	20
Vertical Bend or Sweep ¹				
22.5°, upper bend	4	18	235	20
22.5°, lower bend	4	18	235	20
11.25°, upper bend	4	18	235	20
11.25°, lower bend	4	18	235	20

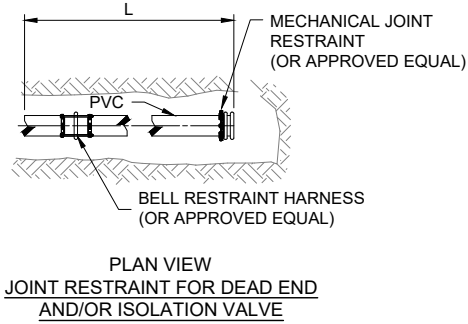


NOTE:
1. INSTALL PER MANUFACTURER'S SPECIFICATIONS
2. SUBMIT JOINT RESTRAINT TABLE BASED ON MANUFACTURER'S SPECIFICATIONS.
(APPROXIMATE LENGTHS PROVIDED BELOW)


WATERLINE JOINT RESTRAINTS AT
VERTICAL / HORIZONTAL BENDS AND GATE VALVES
NOT TO SCALE

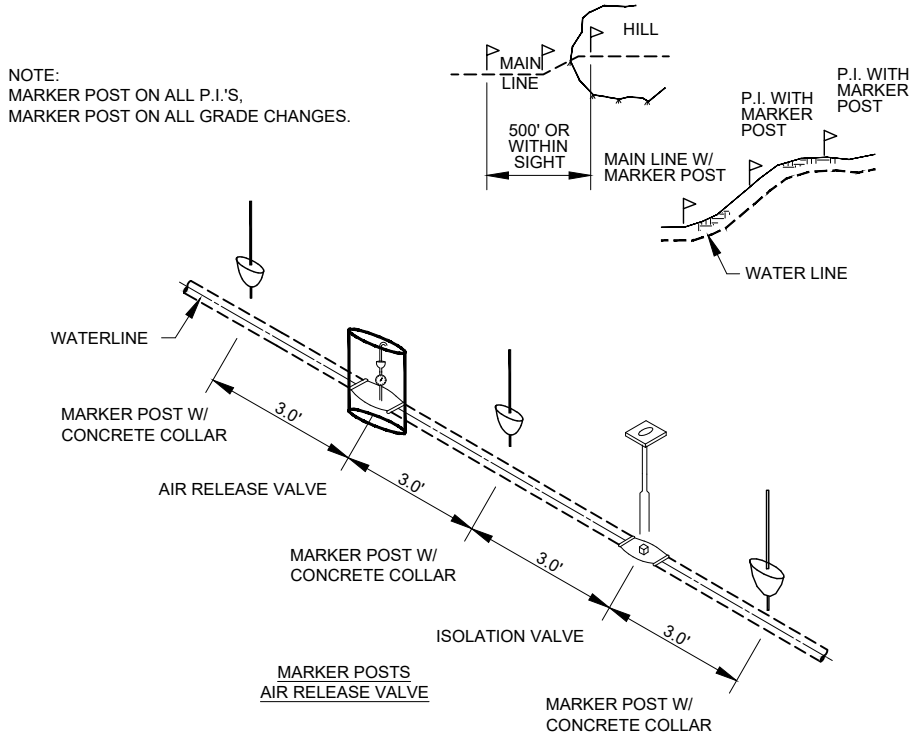


TYPICAL MARKER POSTS
NOT TO SCALE

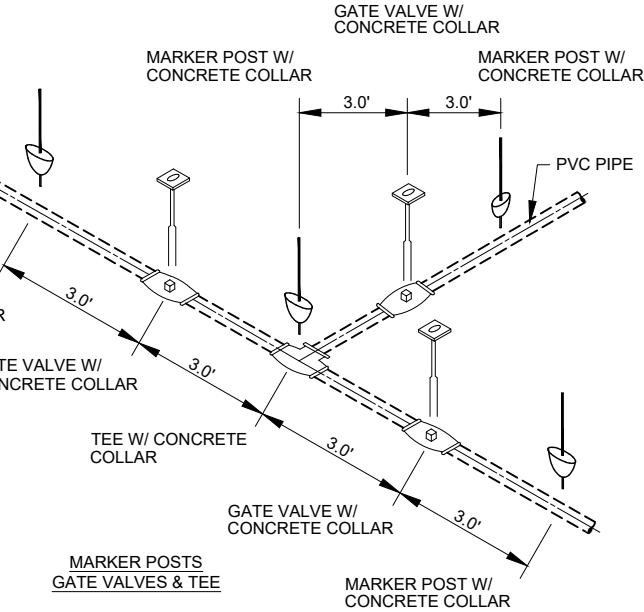

MARKER POSTS
GATE VALVES & TEE

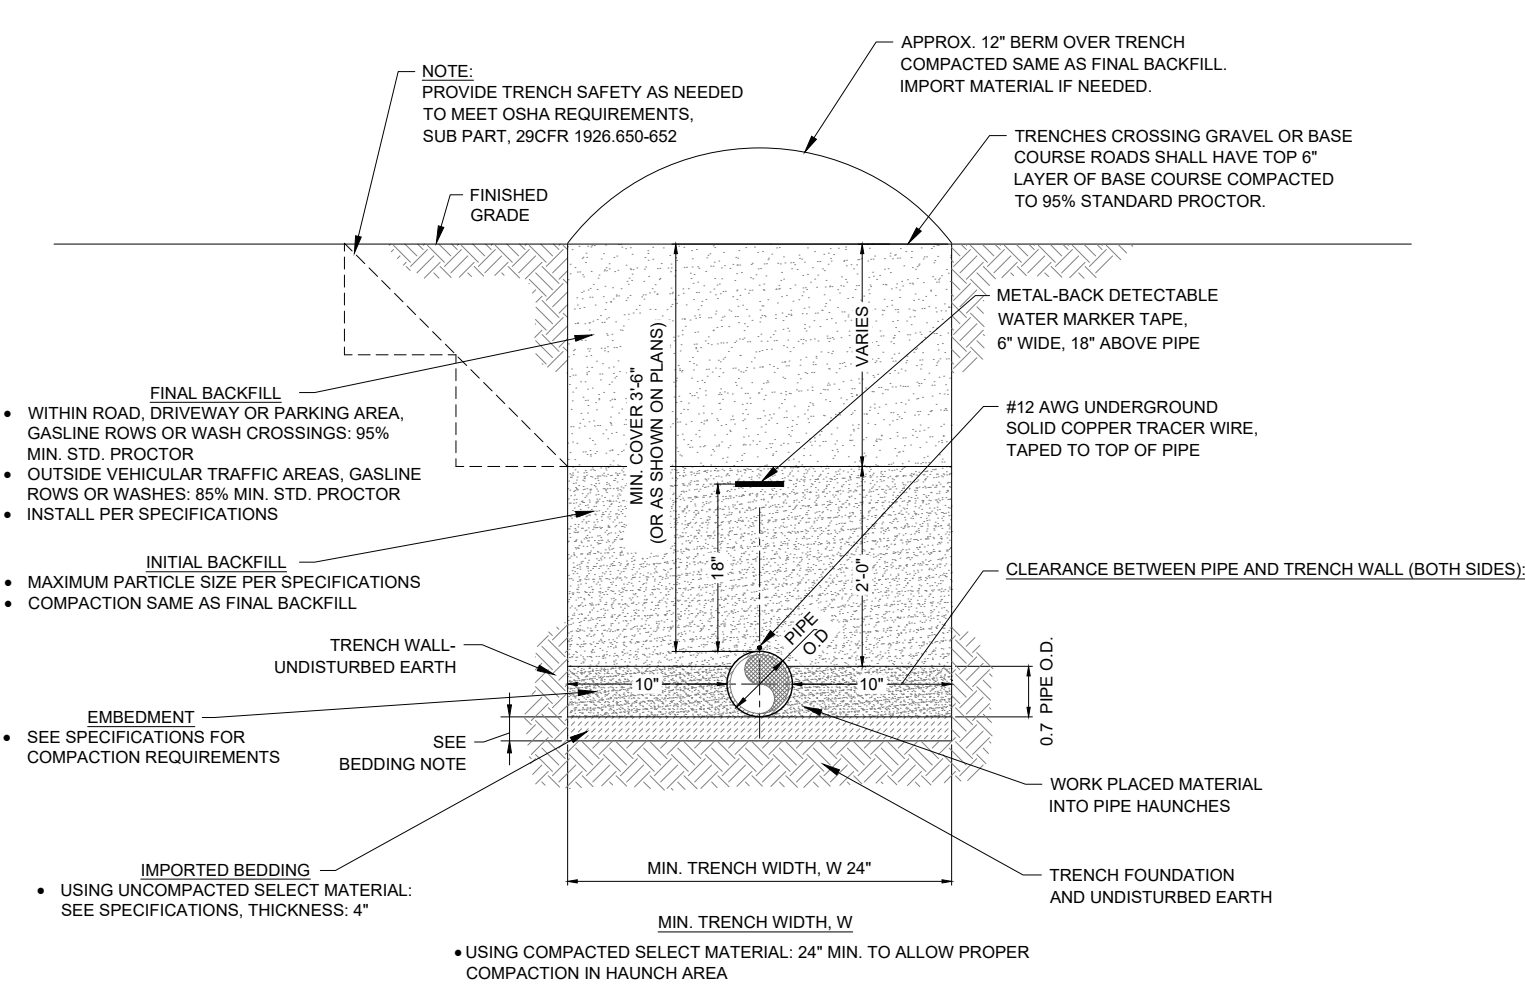

TYPICAL TRENCH DETAIL
NOT TO SCALE

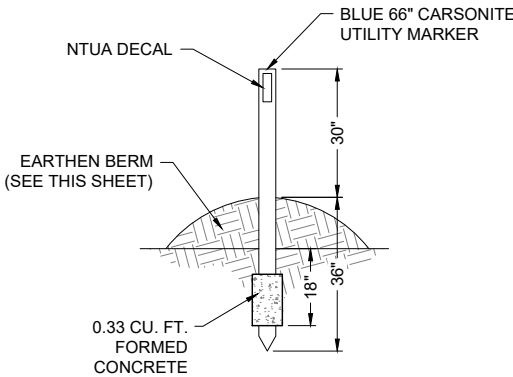


INDIVIDUAL MARKER POST
NOT TO SCALE

P:\BACA-Prewitt (6022883)\BACA Thoreau Well Connection\CAD\DWG\6022883-Thoreau Well Conn Details.dwg
3/4/2021 1:03 PM gaw


THRUST BLOCK DIMENSION SCHEDULE			
Pipe Location	Pipe Size (Inches)	90° Bend H x W	Tee H x W
Pumphouse, Inlet & Outlet	4"	2'-0" x 2'-0"	N/A
Tee, Thoreau Water System Tie-in	4"	N/A	2'-0" x 2'-0"

GENERAL NOTES


1. A SOIL BEARING PRESSURE OF 1,500 psf WAS ASSUMED AS A CONSERVATIVE VALUE, PER RECOMMENDATION FROM OUR GEOTECHNICAL SUB-CONSULTANT.
2. ALL CONCRETE SHALL BE 3000 psi, MINIMUM COMPRESSIVE STRENGTH IN 28 DAYS

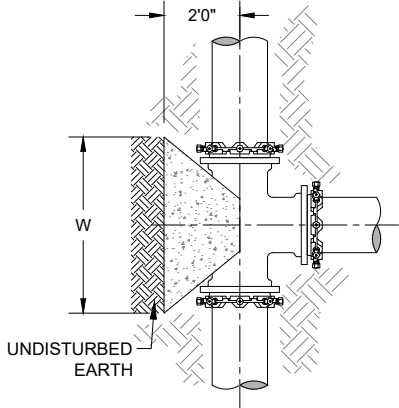


PLAN VIEW
CONCRETE BLOCKING
FOR TEE

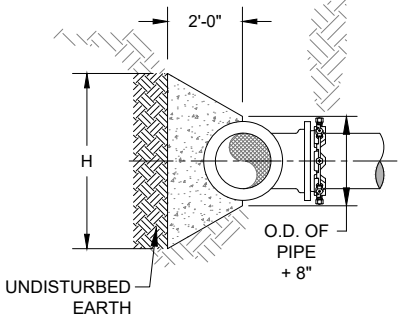

ELEVATION VIEW
CONCRETE BLOCKING
FOR TEE

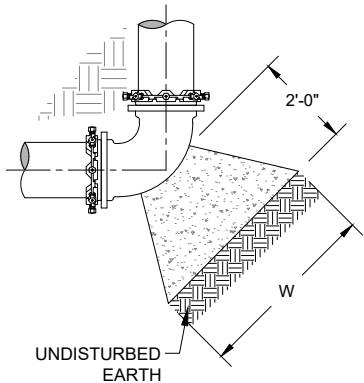


PLAN VIEW
CONCRETE BLOCKING
FOR ELBOW

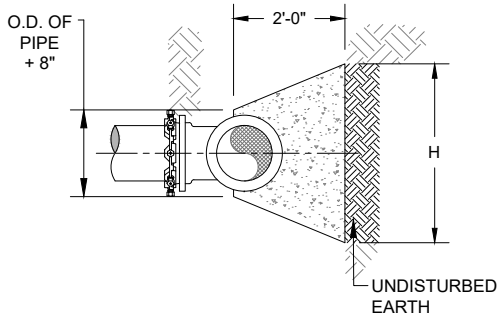

ELEVATION VIEW
CONCRETE BLOCKING
FOR ELBOW

THRUST BLOCK DETAIL
NOT TO SCALE

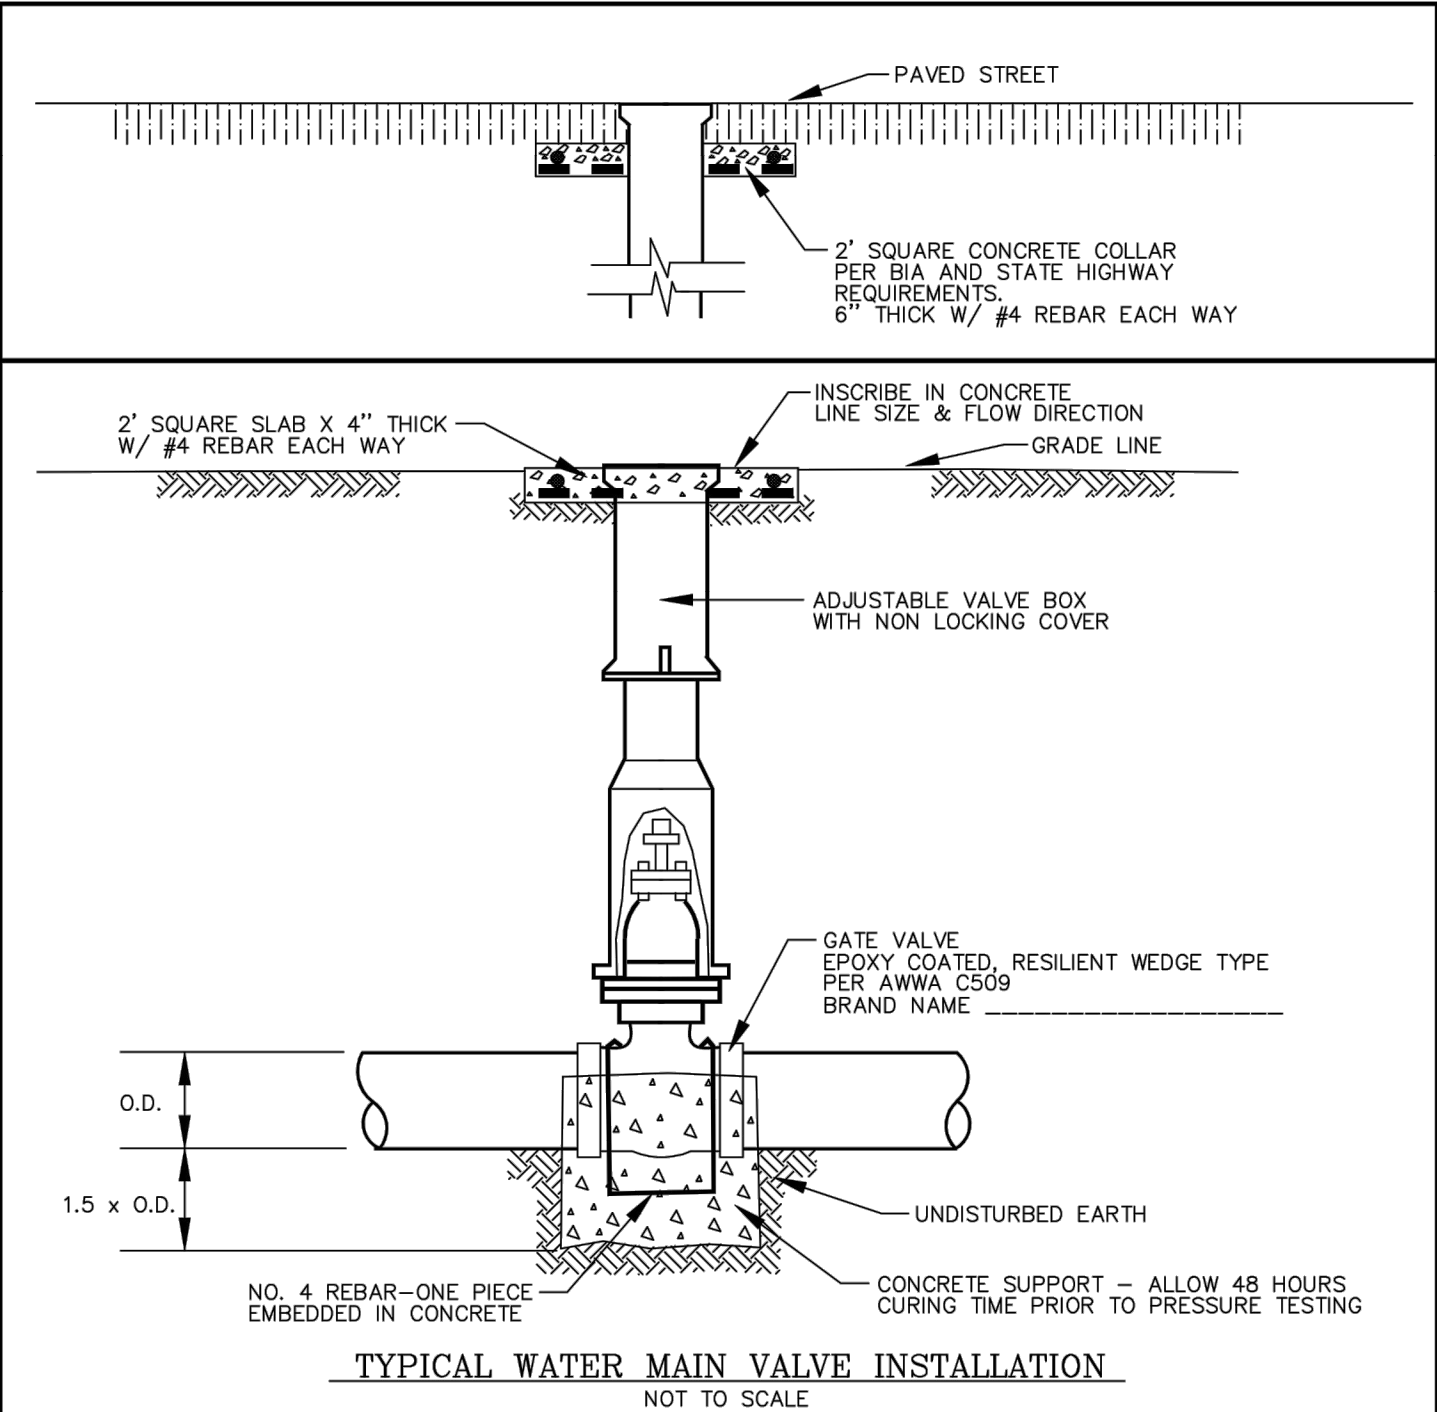

01	7/99	STANDARDIZED	B.M.
REVISION	DATE	BRIEF	BY
U.S. DEPARTMENT OF HEALTH AND HUMAN SERVICES PUBLIC HEALTH SERVICE INDIAN HEALTH SERVICE NAVAJO NATION			
NAVAJO NATION, STANDARD DRAWING NO. W-16 TYPICAL WATER MAIN VALVE INSTALLATION			
OFFICE OF ENVIRONMENTAL HEALTH AND ENGINEERING NAVAJO AREA OFFICE, WINDOW ROCK, ARIZONA			
DRAWN BY: L.S. DATE: 12/92	CHECKED BY: 12-92 DATE: P.S.	APPR. BY: P.S. DATE: 12/92	AUTOCAD DRAWING

Rev#	Date	Description	By	Chkd

SOUDER, MILLER & ASSOCIATES
Engineering • Environmental • Geomatics
Serving the Southwest & Rocky Mountains
5454 Venice Avenue NE, Suite D
Albuquerque, NM 87113
Phone (505) 299-0942 Toll-Free (877) 299-0942 Fax (505) 293-3400
www.soudermiller.com



THE NAVAJO NATION
McKINLEY COUNTY, NEW MEXICO

THOREAU BACA WELL CONNECTION
SECTION 19, T. 14 N., R. 13 W.
GATE VALVE AND THRUST BLOCK DETAILS

**FINAL DESIGN
FOR REVIEW**

THIS DRAWING IS INCOMPLETE
AND NOT TO BE USED FOR
CONSTRUCTION UNLESS IT IS
STAMPED, SIGNED AND DATED

Designed TTT	Drawn AAV	Checked JMG
-----------------	--------------	----------------

Date: March 2021
Scale: Horiz: N/A
Vert: N/A
Project No: 6922883
Sheet: DT-2



3'-6" MIN. COVER (TYP.)

2" CLR. (TOP)

2" CLR. TYP.

#3 HOOP EACH FACE, PROVIDE 18" LAP ALL REINFORCING TO CLEAR FLANGE COLLAR OR OPENING BY 2"

SEE WALL ANCHOR DIMENSION SCHEDULE FOR SIZE, REINFORCEMENT REQUIRED

4 - #6 REBAR EACH WAY, EACH FACE

3" CLR. (BOTTOM)


W

H

FINISHED GRADE

CONCRETE WALL ANCHOR BLOCK FOR USE
HDPE TRANSITION RESTRAINT
NOT TO SCALE

P:\BACA-Prewitt (6022883)\BACA Thoreau Well Connection\CAD\DWG\6022883-Thoreau Well Conn Flush Valve Details.dwg
3/4/2021 1:13:24 PM aw

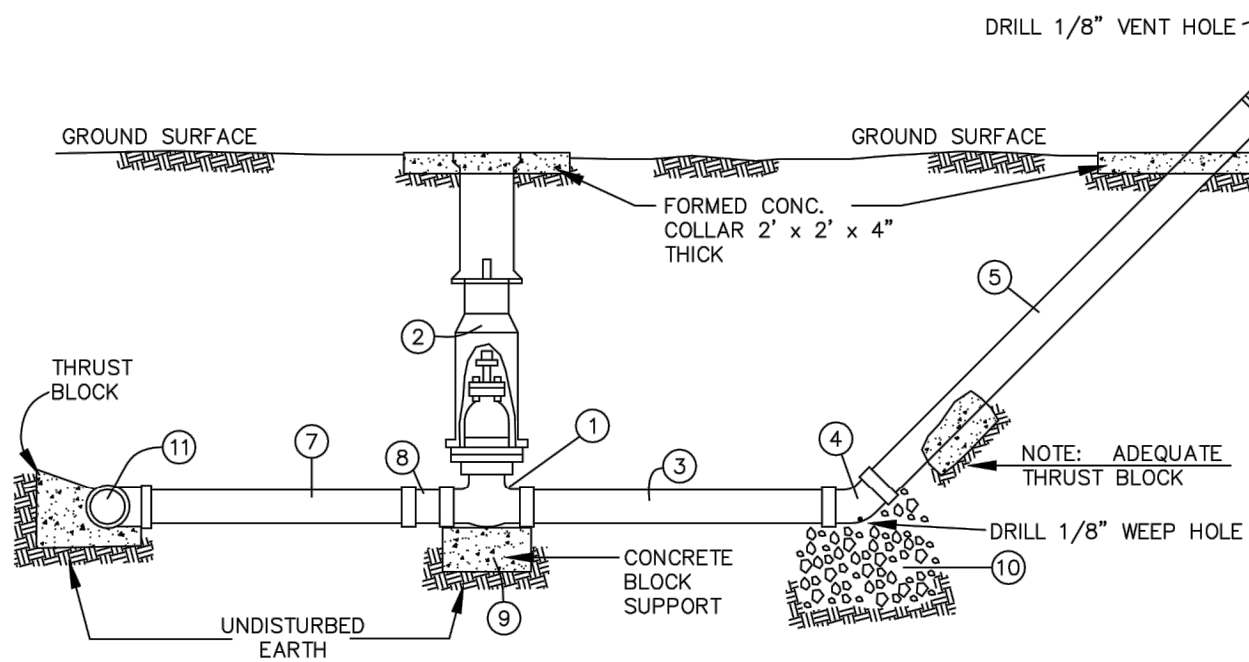


STANDARD FLUSH VALVE DETAIL
NOT TO SCALE

B I L L O F M A T E R I A L S		
ITEM	QUAN.	DESCRIPTION
1.	1	VALVE, GATE 2" F.I.P.T. C.I. w/ SQ. NUT
2.	1	VALVE, BOX 5 1/4" C.I., 36"-48"
3.	1	PIPE, 2" x 3' (MIN.), GALV. IRON
4.	1	ELBOW, 2"-45° GALV. IRON w/ 1/8" WEEP HOLE
5.	1	PIPE, 2" GALV. IRON x CUT TO LENGTH AS NEEDED
6.	1	CAP, 2" GALV. IRON w/ 1/8" VENT HOLE
7.	1	PIPE 2" PVC CUT TO LENGTH AS NEEDED
8.	1	ADAPTER, 2" BELL x MIPT, PVC
9.	1	BLOCK SOLID 4" x 8" x 16"
* 10.	1	FILTER ROCK, 12" x 12" x 12" (0.037 CU. YD.)
* 11.	1	MAIN LINE, SADDLE OR TEE

* NOT ON STANDARD LIST

NOTE:
1. WRAP BURIED GALV. PIPING WITH POLYGEN TAPE.

1	7/99	STANDARDIZED	B.M.
REVISION	DATE	BRIEF	BY
U.S. DEPARTMENT OF HEALTH AND HUMAN SERVICES PUBLIC HEALTH SERVICE INDIAN HEALTH SERVICE NAVAJO NATION			
NAVAJO NATION, STANDARD DRAWING NO. W-1 2" FLUSH VALVE LIST NO. 006502			
OFFICE OF ENVIRONMENTAL HEALTH AND ENGINEERING NAVAJO AREA OFFICE, WINDOW ROCK, ARIZONA			
DRAWN BY: L.S. DATE: 11/92	CHECKED BY: P.S. DATE: 2/93	APPR. BY: T.M. DATE: 2/93	AUTOCAD DRAWING

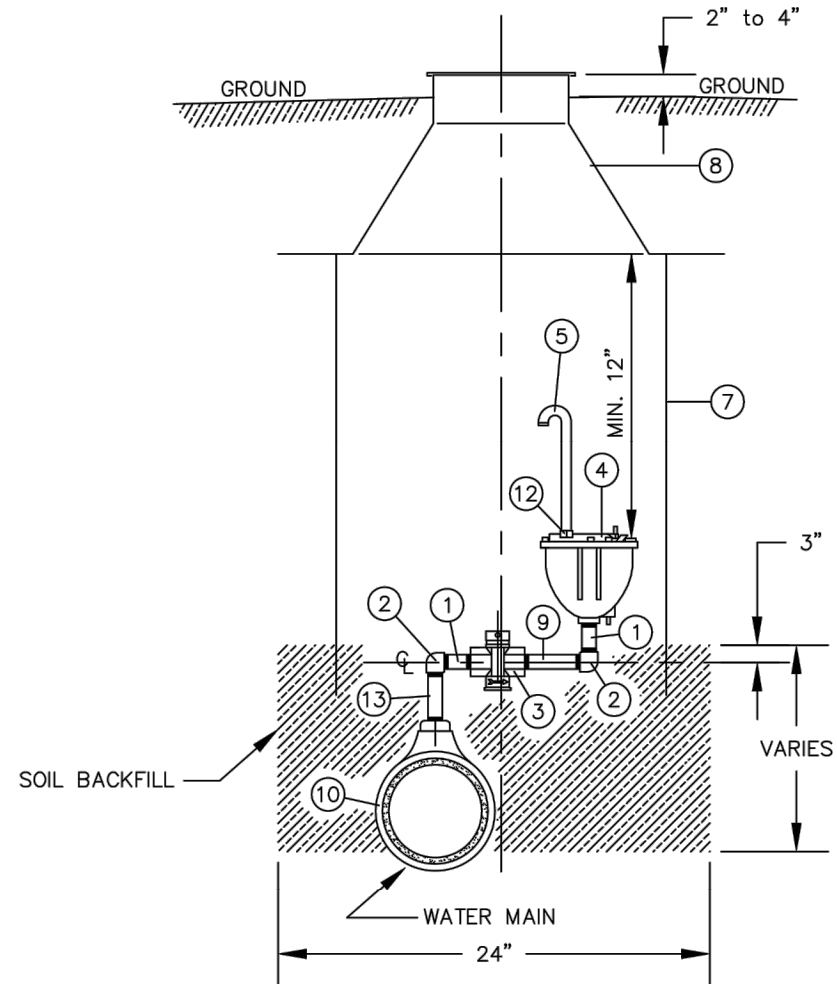

STANDARD AIR RELEASE VALVE DETAIL
NOT TO SCALE


B I L L O F M A T E R I A L S		
ITEM	QUAN.	DESCRIPTION
1.	2	NIPPLE, 1" x CLOSE, GALV.
2.	2	ELBOW, 1"-90°, GALV.
3.	1	CURBSTOP VALVE, 1" FIPT
4.	1	AIR RELEASE VALVE, 1" IN x 1/2" OUT BRAND NAME _____
5.	1	3/8" I.D. COPPER PIPE, 12"
7.	1	METER BOX, 20" DIAMETER
8.	1	METER BOX LID WITH FROST COVER
9.	1	NIPPLE, 1" x 3", GALV.
* 10.	1	TEE OR SADDLE, 1" TAP
12.	1	ADAPTER, 1/2" MIPT x 1/2" COMP.
13.	1	NIPPLE, 1" x 6", GALV.

* NOT ON STANDARD LIST


2	8/01	DELETED STATIONARY ROD AND GRAVEL	R.B.M.
1	7/99	STANDARDIZED	B.M.
REVISION	DATE	BRIEF	BY
U.S. DEPARTMENT OF HEALTH AND HUMAN SERVICES PUBLIC HEALTH SERVICE INDIAN HEALTH SERVICE NAVAJO NATION			
NAVAJO NATION, STANDARD DRAWING NO. W-2 AIR RELEASE VALVE LIST NO. 001434			
OFFICE OF ENVIRONMENTAL HEALTH AND ENGINEERING NAVAJO AREA OFFICE, WINDOW ROCK, ARIZONA			
DRAWN BY: L.S. DATE: 11/92	CHECKED BY: P.S. DATE: 2/93	APPR. BY: P.S. DATE: 2/93	AUTOCAD DRAWING

NOTES:

1. PRESSURE GAUGES AND HONEYWELL CONTROL ORDERED SEPARATELY ACCORDING TO WORKING PRESSURE
2. PIPE AND CAST IRON VALVES/FITTINGS PRIMED AND PAINTED BLUE, ORDER PAINT AND PRIMER SEPARATELY
3. HIGH PRESSURE RATED GAUGES AND VALVES ARE REQUIRED FOR PRESSURES > 150 PSI
4. WRAP EXTERIOR D.I. PIPING WITH POLYGEN TAPE

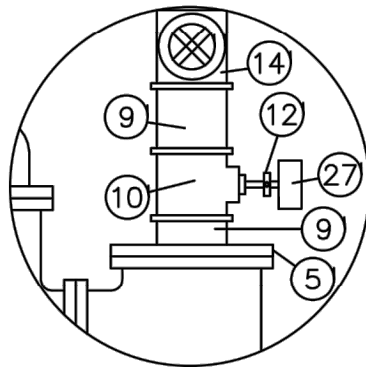

DETAIL "A"
N.T.S.

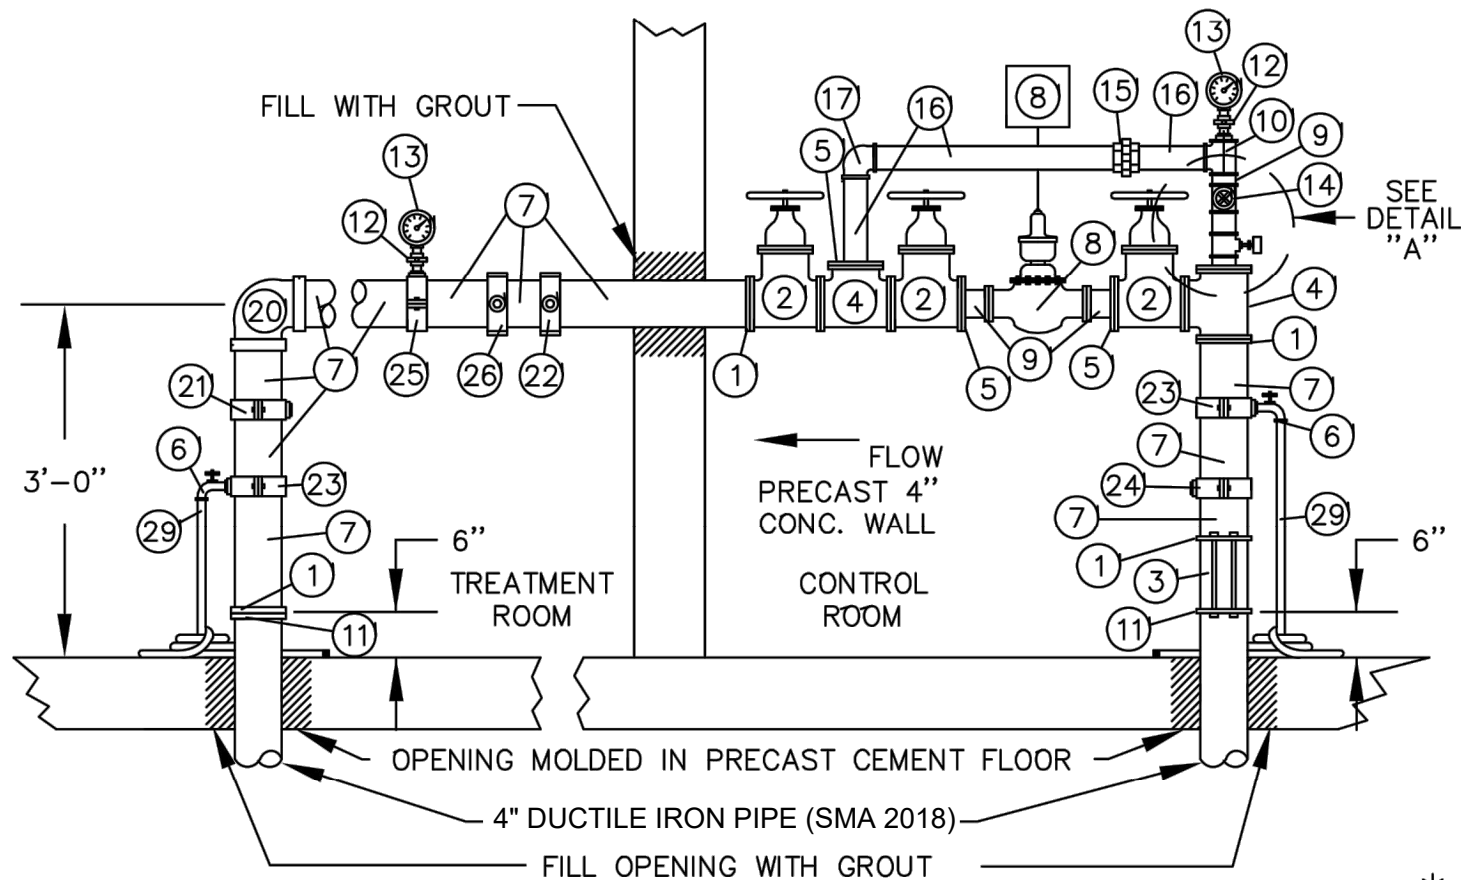

4" FLANGED PUMPHOUSE PIPING FOR FLOWS OF 50 TO 250* GPM
(125 # FLANGES) HEAD LOSS = 13 FT. @ 250 GPM

* DIFFERENT METER REQUIRED FOR FLOWS IN EXCESS OF 160 GPM OR PRESSURES > 150 PSI

NOTE: PROJECT SPECIFIC MODIFICATIONS WERE MADE TO THIS DETAIL BY SMA FOR THE PUMP HOUSE TO BE CONNECTED TO THE THOREAU WELL DESIGNATED (SMA 2018).

3	1/06	ADDED METER HIGH SPEED PICK UP & ACT-PAK	D.S.
2	1/00	ADDED FIELD FLANGE TO MATERIALS LIST	R.B.M.
REVISION	DATE	BRIEF	BY

ITEM	QUAN.	DESCRIPTION
1	4	COMPANION FLANGE, 4" FIPT X 9" FACE
2	3	GATE VALVE, 4" FLANGED, C.I. W/ WHEEL
3	1	CHECK VALVE, 4" SILENT, WAFER STYLE W/ BOLTS FLANGES
4	2	TEE, 4" FLANGED, C.I.
5	4	REDUCING FLANGE, 2"FIPT X 9"FACE
6	2	HOSE BIBB, 3/4" W/BACKFLOW PREVENTION
7	3	4" DUCTILE IRON PIPE (CUT AS NEEDED) (SMA 2018)
8	1	2" TURBINE WATER METER W/ACT-PAK, (SENSUS W160 DR/HSP) 150 PSI MAX. (W/COMPANION FLANGES)
9	5	NIPPLE, 2"X 3", G.I. (THREADED)
10	2	2"X 2"X 2" TEE W/2"X 3/4" & 3/4"X 1/4" BUSHINGS (FOR PRESSURE GAUGE & HIGH PRESSURE CUTOFF SWITCH)
11	2	FIELD FLANGE
12	3	VALVE, PRESSURE COCK, 1/4"
13	2	PRESSURE GAUGE
14	1	GATE VALVE, 2" BRASS (FEMALE THREADED ENDS)
15	1	UNION, 2" G.I.
16	3	G.I. PIPE, 2" (CUT & THREAD IN FIELD)
17	1	ELBOW, 90°, 2" G.I.
18		
19		
20	1	ELBOW, 90°, 4" G.I.
21	1	SADDLE, 4"X 1" (FOR CHLORINE INTRODUCTION)
22	1	SADDLE, 4"X 1", ROTATED 90° (FOR CHLORINE SUPPLY)
23	2	SADDLE, 4"X 3/4", (FOR HOSE BIBB)
24	1	SADDLE, 4"X 3/4", (FOR SEQUESTERING TREATMENT IF NEEDED)
25	1	SADDLE, 4"X 1", W/ 1"X 1/4" BUSHING (FOR PRESSURE GAUGE)
26	1	SADDLE, 4"X 3/4" ROTATED 90° W/3/4"X 1/2" BUSHING, (FOR FLUORIDE INTRODUCTION)
27	1	HIGH PRESSURE CUT-OFF
28		
29	2	GARDEN HOSE, 10', HOSE BIBB X PLAIN END

U.S. DEPARTMENT OF HEALTH AND HUMAN SERVICES
PUBLIC HEALTH SERVICE
INDIAN HEALTH SERVICE
NAVAJO NATION

NAVAJO NATION,
STANDARD DRAWING NO. W-14
4" PUMPHOUSE PIPING
LIST NO. 901550

OFFICE OF ENVIRONMENTAL HEALTH AND ENGINEERING
NAVAJO AREA OFFICE, WINDOW ROCK, ARIZONA

DRAWN BY: L.S.	CHECKED BY: P.S.	APPR. BY: P.S.	AUTOCAD
DATE: 1/93	DATE: 1/93	DATE: 1/93	DRAWING

STANDARD
DRAWING

THIS DRAWING IS INCOMPLETE
AND NOT TO BE USED FOR
CONSTRUCTION UNLESS IT IS
STAMPED, SIGNED AND DATED

Designed TTT	Drawn AAV	Checked JMG
-----------------	--------------	----------------



Date: March 2021

Scale: Horiz: N/A

Vert: N/A

Project No: 6922883

Sheet: DT-6

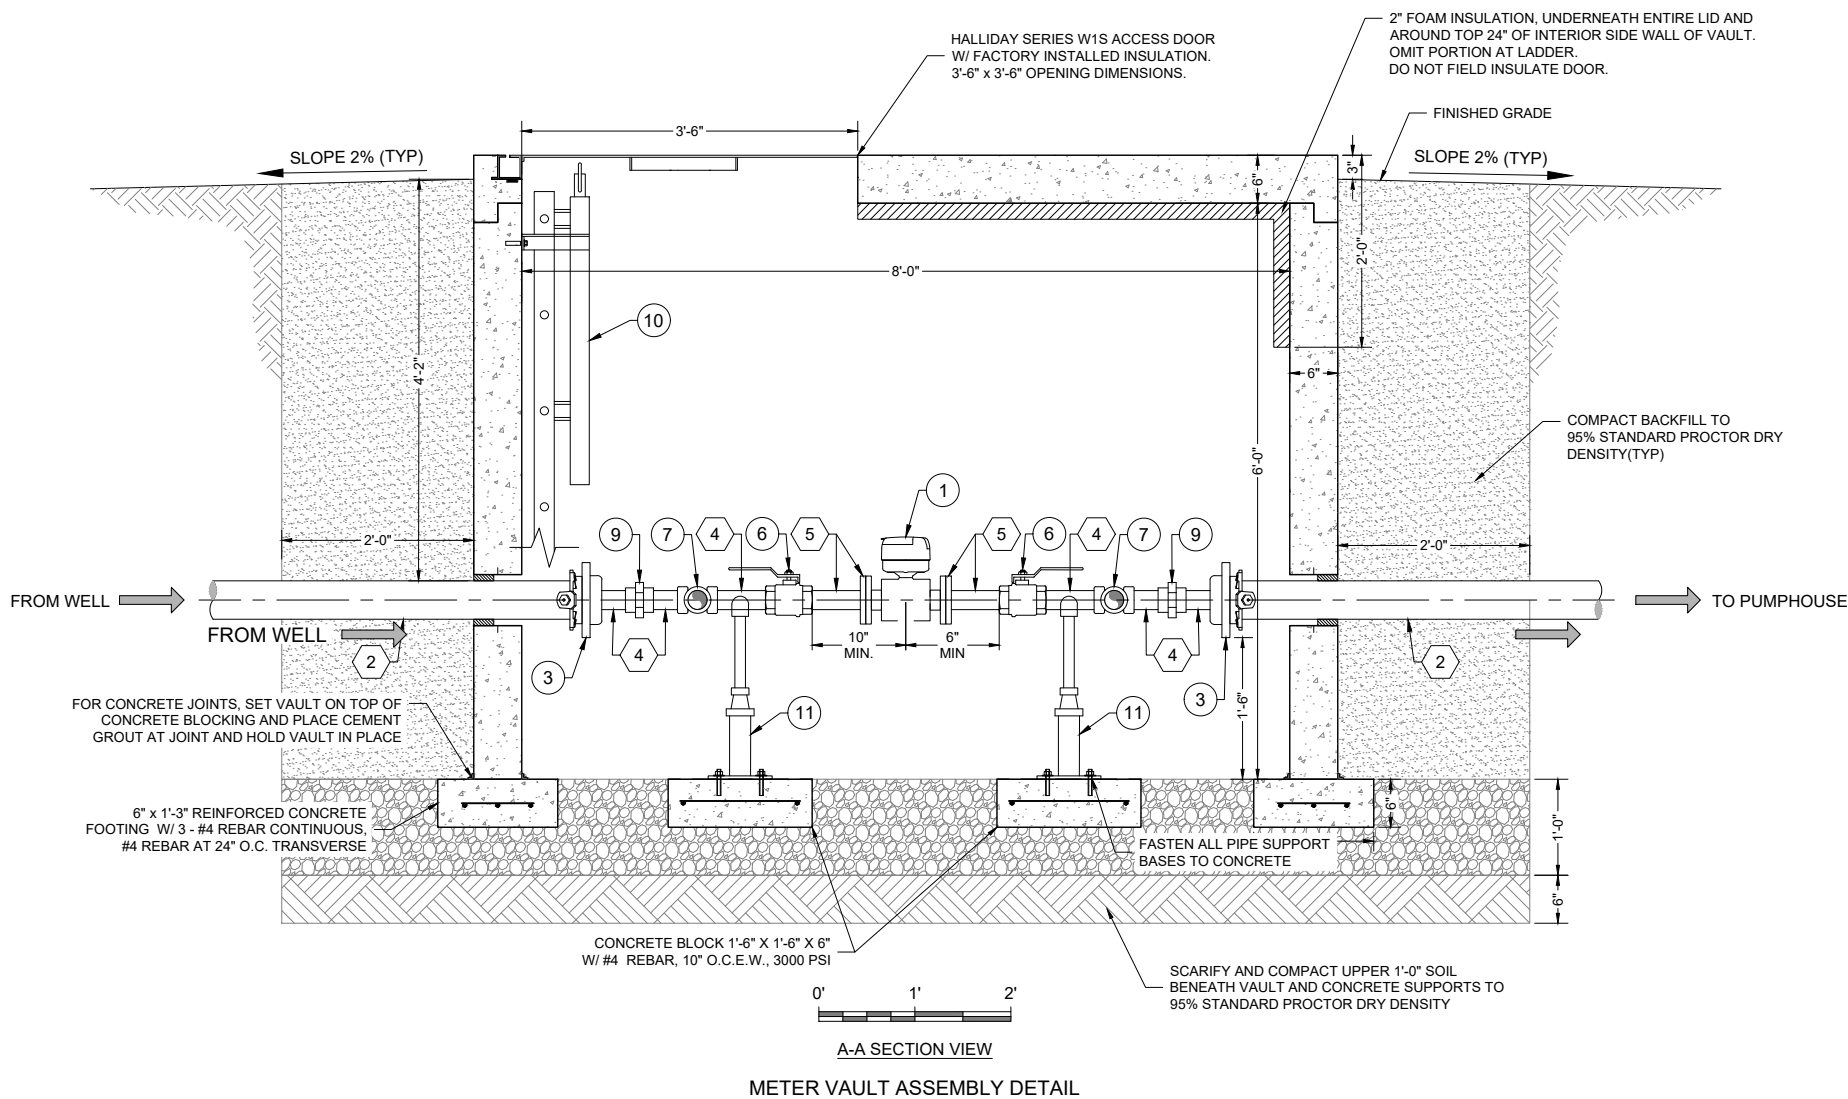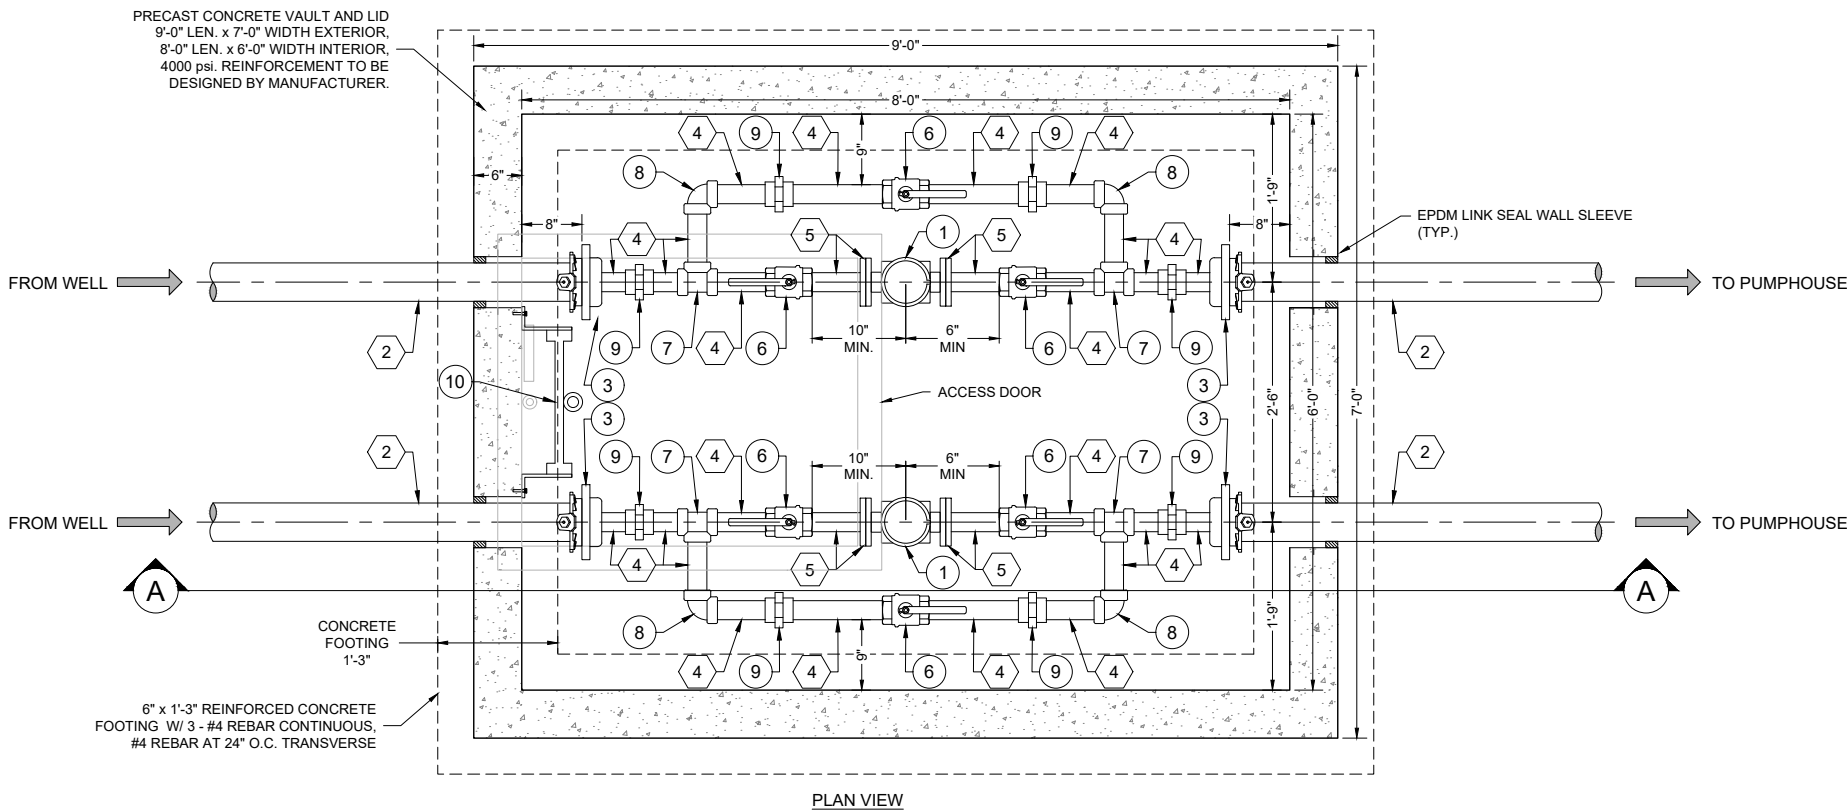


KEYED NOTES - METER VAULT ASSEMBLY

Item No.	Description
1	2" EVOQ MAG METER
2	4" DUCTILE IRON PIPE
3	4" x 2" MJ THREADED CAP
4	2" STAINLESS STEEL PIPE, NPT
5	2" FL x PE STAINLESS STEEL SPOOL, NPT
6	2" BALL VALVE, SS 304, NPT
7	2" TEE, SS 304, NPT
8	2" 90° BEND, SS 304, NPT
9	2" UNION, SS 304, NPT
10	ALUMINUM LADDER W/ SAFETY POST ANCHORED TO VAULT
11	ADJUSTABLE PIPE SUPPORT W/ U-SHAPED CRADLE

- NOTES:
- METERS SHALL HAVE MINIMUM 10" LENGTH STRAIGHT 2" PIPE UPSTREAM AND 6" LENGTH STRAIGHT 2" PIPE DOWNSTREAM AS MEASURED FROM CENTER OF METER.
 - SOME PIPE SUPPORTS NOT SHOWN FOR CLARITY. ENTIRE PIPING ASSEMBLY SHALL BE SUPPORTED.

P:\BACA-Prewitt (6022883)\BACA Thoreau Well Connection\CAD\DWG\6022883-Thoreau Well Conn Pumphouse.dwg
3/4/2021 1:13:45 PM jmg

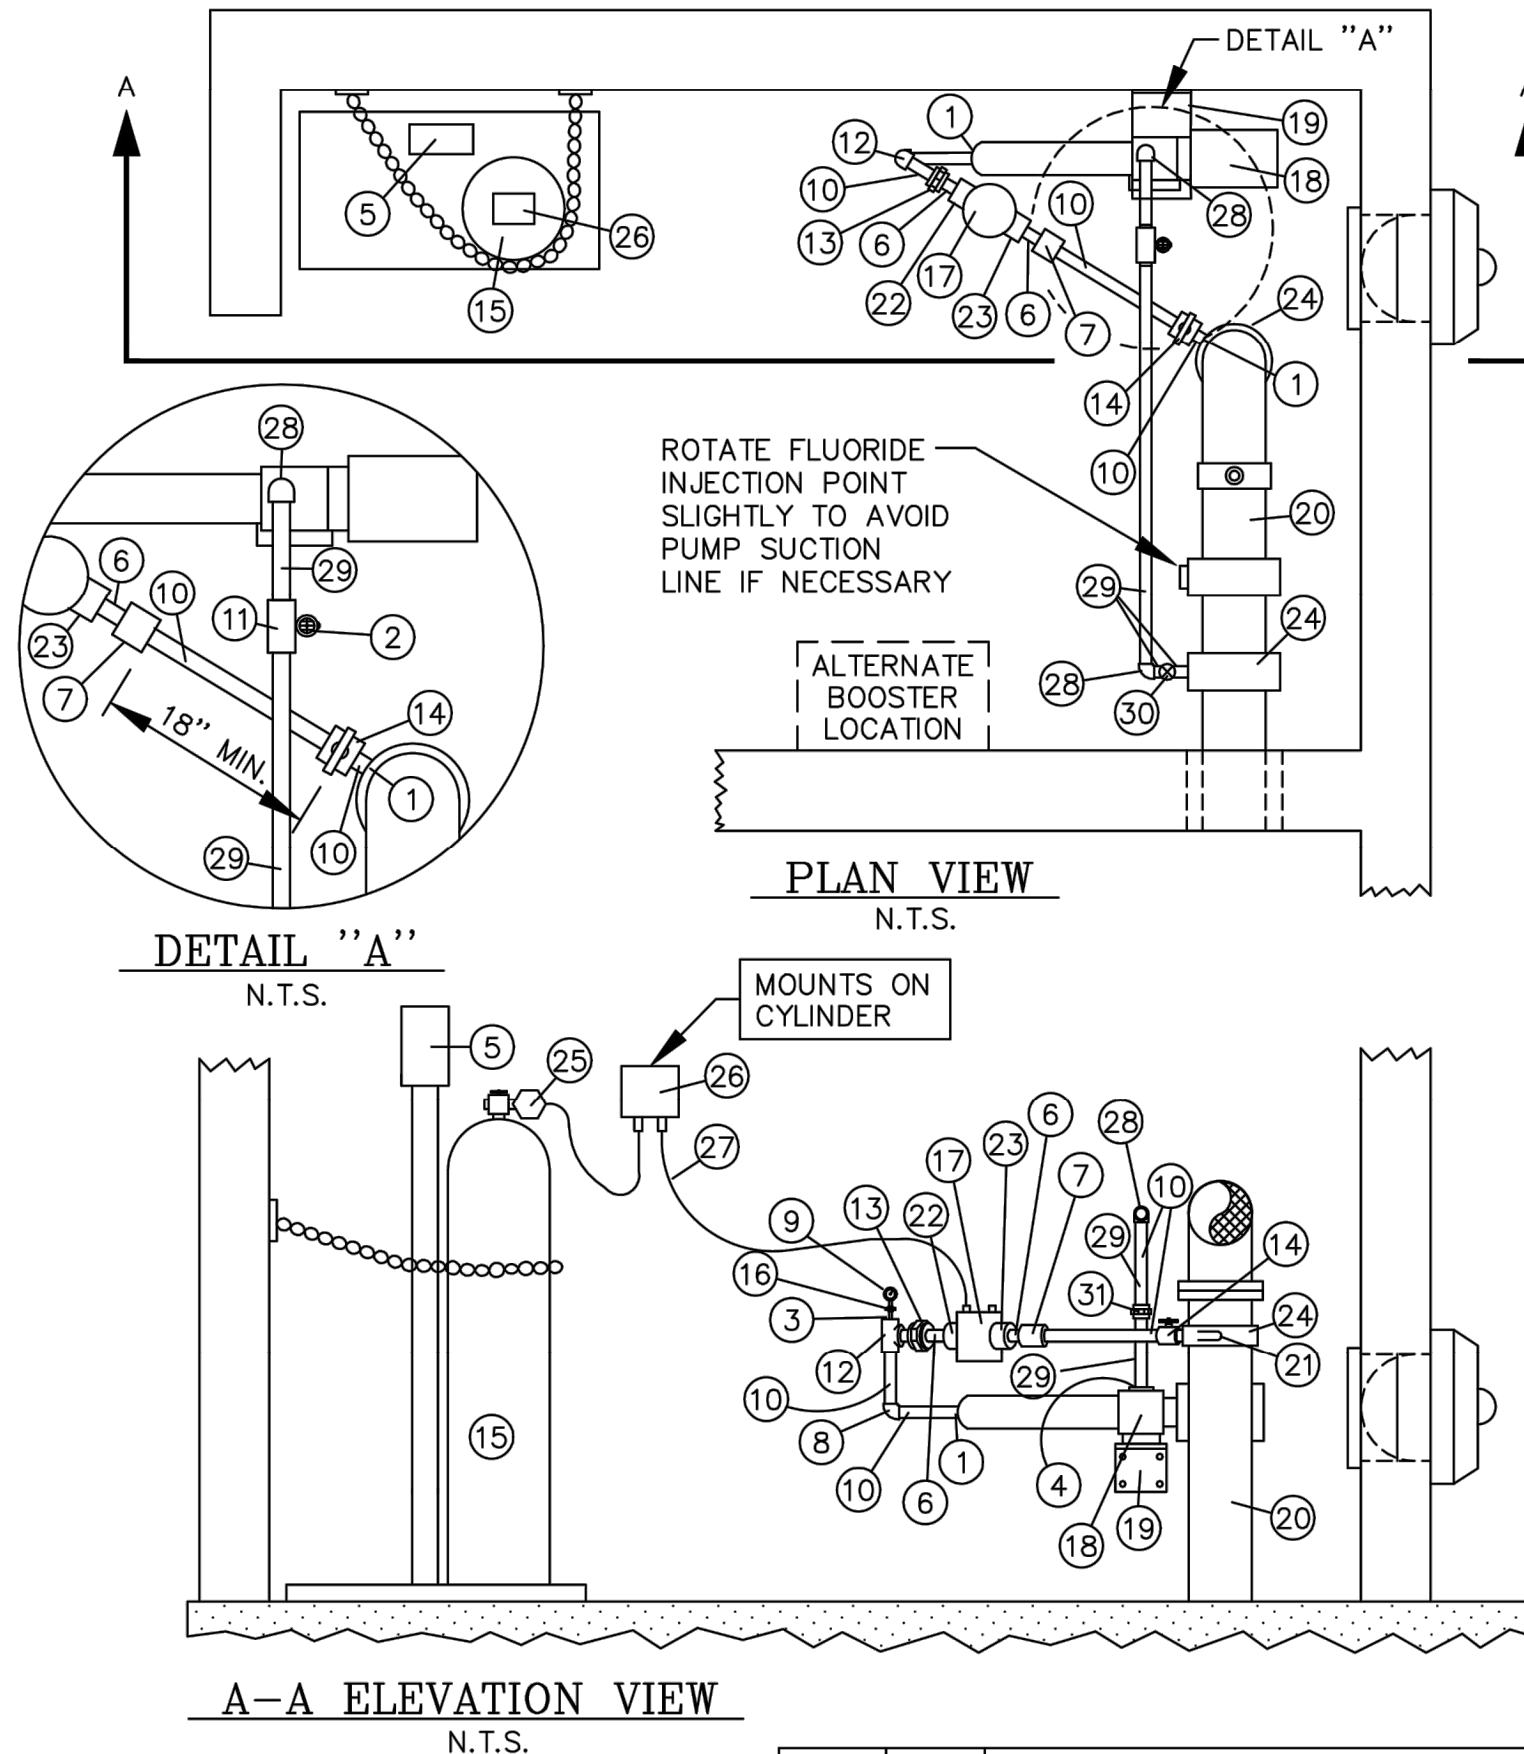

ITEM	QUAN.	DESCRIPTION
1	3	ADAPTER 1" S X MIPT SCH. 80 PVC
2	1	BIBB HOSE, 3/4" MIPT BRASS (W/ BACKFLOW PREVENTOR)
3	1	BUSHING 1" S X 1/4" FIPT SCH. 80 PVC
4	1	BUSHING 1-1/4" X 1" GALV.
*5	1	CHLORINE SCALE
6	2	BUSHING 1" S X 3/4" FIPT SCH. 80 PVC
7	1	COUPLING 1" SLIP SCH. 80 PVC
8	1	ELBOW 90° 1" SLIP SCH. 80 PVC
9	1	GAUGE GLYCER 1/4" 0-350
10	AS NEEDED	PIPE 1" CUT TO FIT SCH. 80 PVC
11	1	STAINER 1" X 1" FIPT GALV.
12	1	TEE 1" SLIP SCH. 80 PVC
13	1	UNION 1" SLIP SCH. 80 PVC
14	1	BALL VALVE 1" SLIP SCH. 80 PVC
*15	1	GAS CHLORINE CYLINDER
16	1	VALVE PRESSURE COCK 1/4" MIPT BRASS
*17	1	EJECTOR UNIT S-10 CHLORINATOR
*18	1	JACUZZI-BOOSTER PUMP (MODEL PER SPEC)
19	1	BOOSTER PUMP-BRACKET
*20	AS NEEDED	PUMP HOUSE PIPING 4" ±
21	1	1/2" PVC-SOLUTION TUBE
22	1	NOZZLE-EJECTOR (MODEL PER SPEC)
23	1	TAILWAY-EJECTOR (MODEL PER SPEC)
24	2	SADDLE 4" X 1" IPT
25	1	PRESSURE REGULATOR
*26	1	CONTROL UNIT, ROTOMETER
27	AS NEEDED	TUBING
28	2	ELBOW 90° 1" FIPT SCH. 40 G.I.
29	AS NEEDED	PIPE 1" CUT AND THREADED TO FIT, G.I.
30	1	GATE VALVE, 1" BRASS, FIPT
31	1	UNION, 1" SCH. 40 G.I.

* NOT ON STANDARD LIST

- NOTE: 1. BOOSTER INLET PIPING TO BE G.I. TO PROVIDE INCREASED SUPPORT.
2. BOOSTER PUMP INSTALLER TO MAKE TAP FOR CHLORINE AND FLUORIDE PUMP.
3. GAS CHLORINATION SHALL BE CONSIDERED FOR ALL FLOWRATES GREATER THAN 50 GPM.

U.S. DEPARTMENT OF HEALTH AND HUMAN SERVICES
PUBLIC HEALTH SERVICE
INDIAN HEALTH SERVICE
NAVAJO NATION


NAVAJO NATION,
STANDARD DRAWING NO. W-15
GAS CHLORINATION
LIST NO. 902000

OFFICE OF ENVIRONMENTAL HEALTH AND ENGINEERING
NAVAJO AREA OFFICE, WINDOW ROCK, ARIZONA


DRAWN BY: L.S.	CHECKED BY: P.S.	APPR. BY: P.S.	AUTOCAD
DATE: 1/93	DATE: 1/93	DATE: 1/93	DRAWING

1	7/99	STANDARDIZED	B.M.
REVISION	DATE	BRIEF	BY

P:\BACA-Prewitt (6922883)\BACA Thoreau Well Connection\CAD\DWG\6922883-Thoreau Well Conn Pumphouse.dwg
3/4/2021 10:51 PM gaw

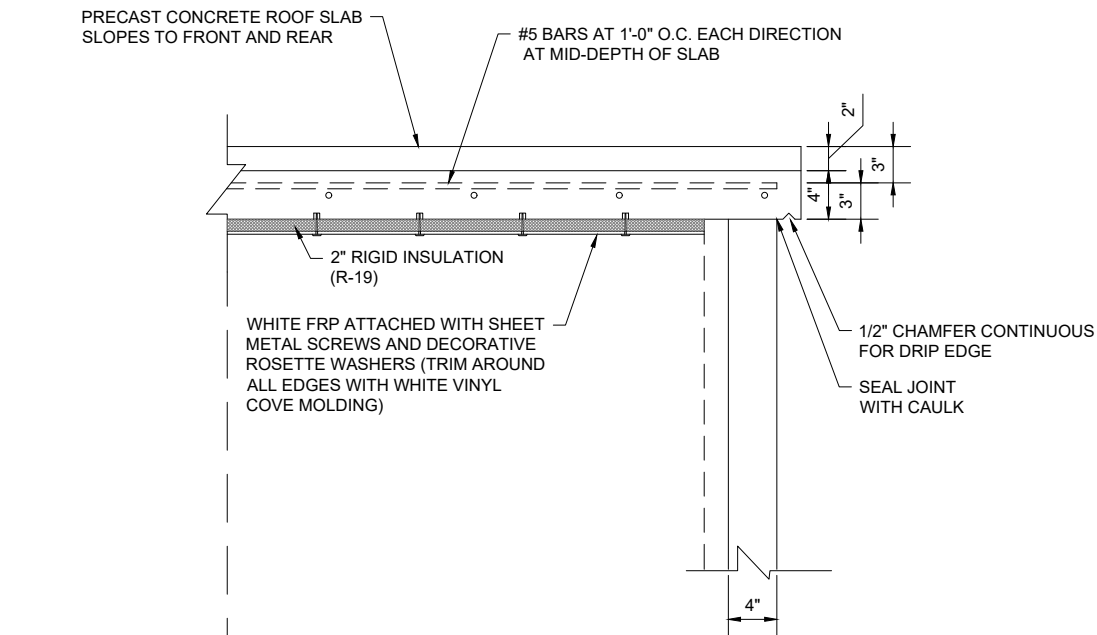


**ROOF CONNECTION
DETAIL A**
NOT TO SCALE

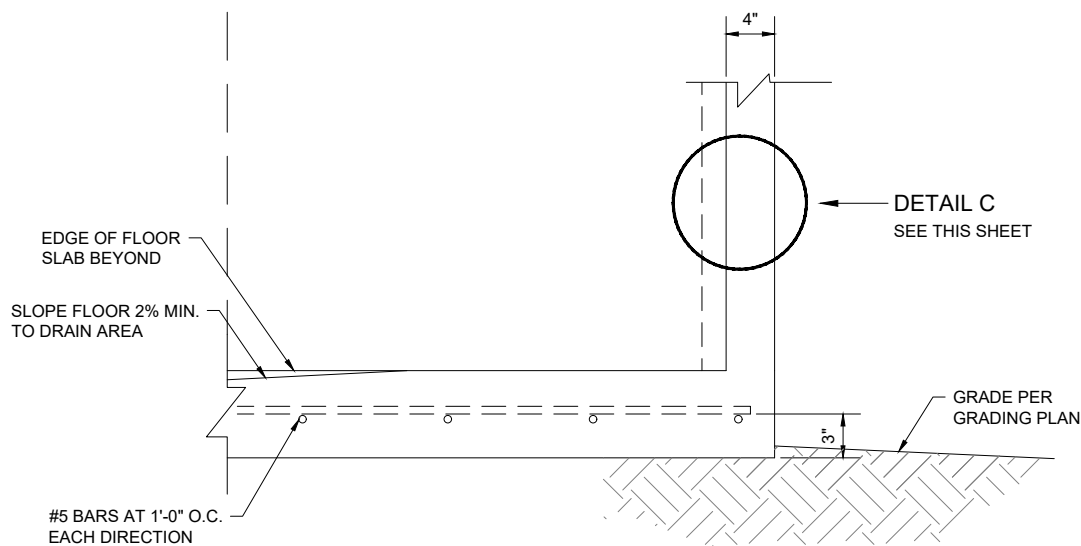


NOTE: REBAR AT LIFT JOINTS ARE #6 REBAR, 12" SEPARATION, CENTERED ON LIFT POINTS. REBARS ARE CENTERED THE ENTIRE LENGTH AND WIDTH OF SLAB (BOTH DIRECTIONS OF EACH LIFT POINT)


**FLOOR CONNECTION
DETAIL B**
NOT TO SCALE

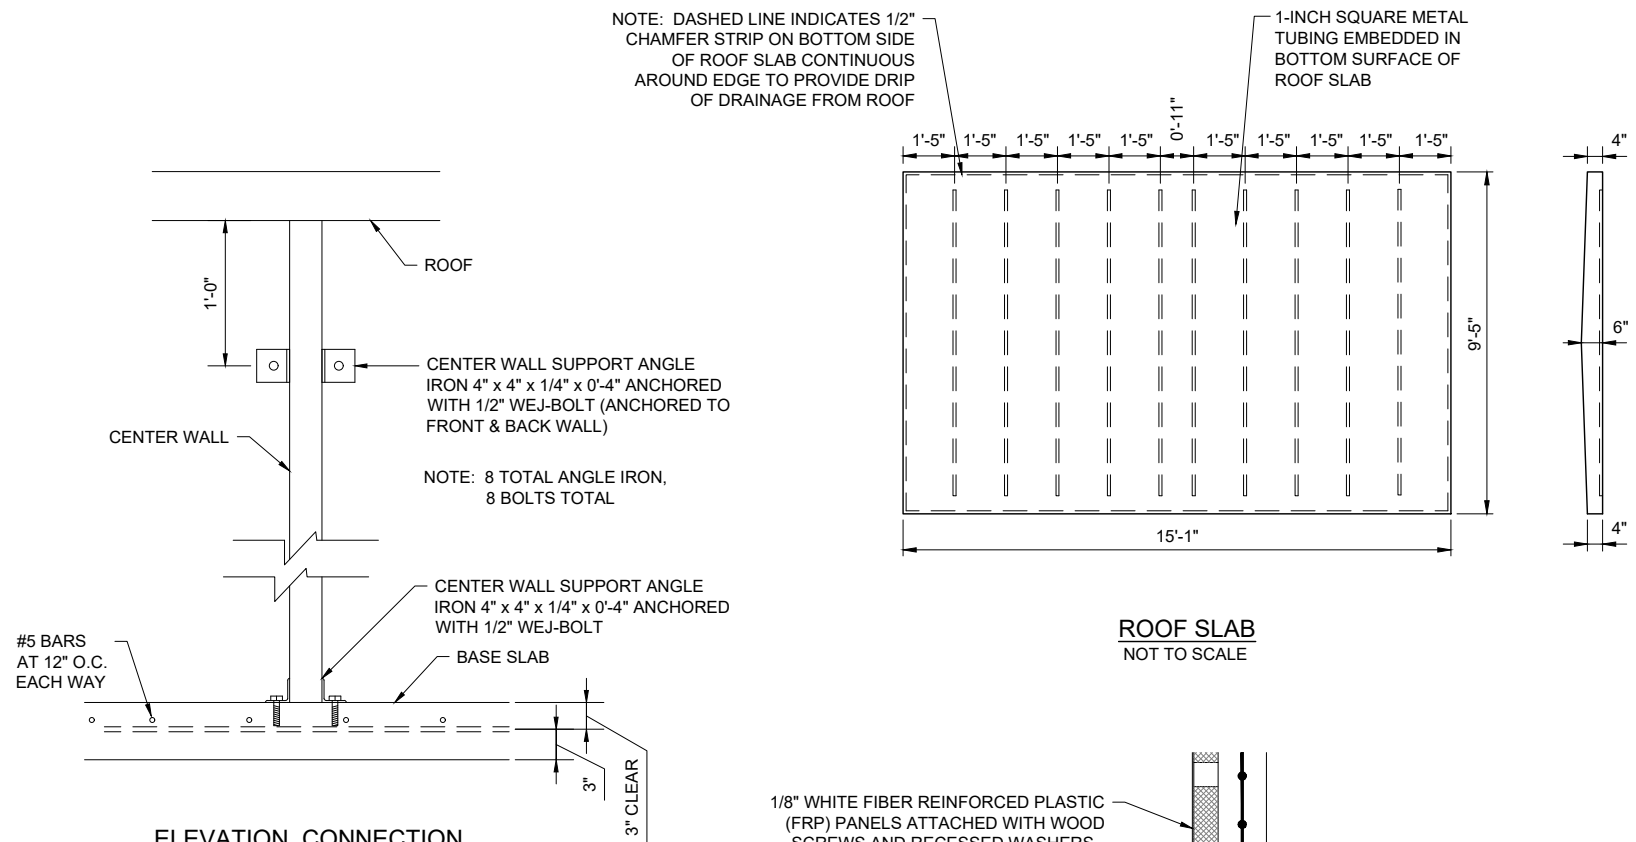


**ELEVATION CONNECTION
ANGLE IRON
AT CENTER WALL**
NOT TO SCALE

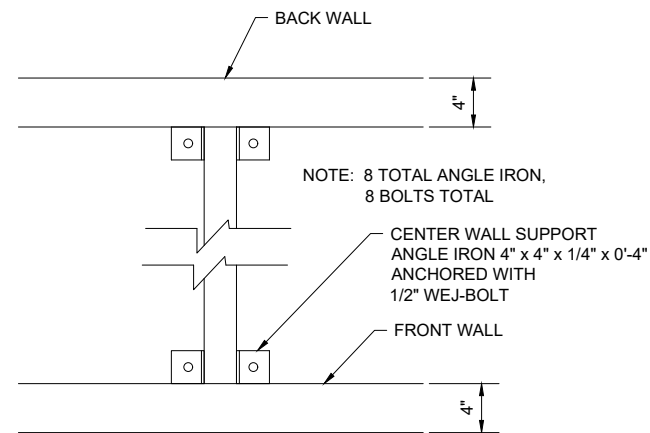


**PLAN CONNECTION
ANGLE IRON
AT CENTER WALL**
NOT TO SCALE

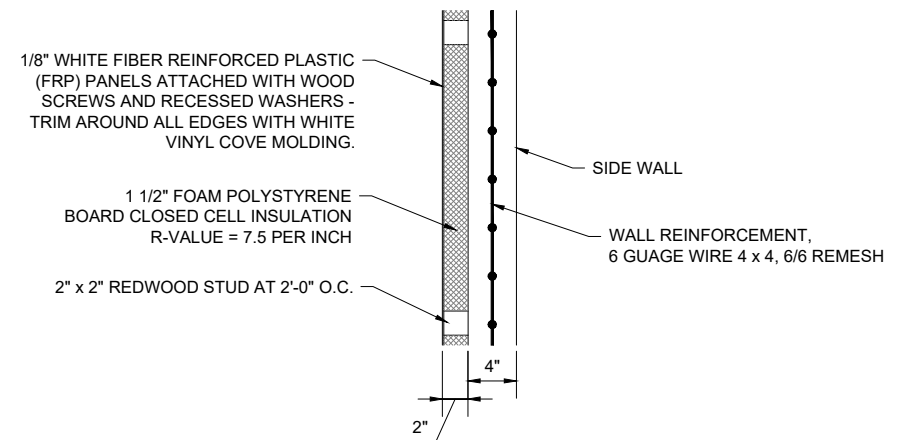

**WALL SECTION
DETAIL C**
NOT TO SCALE

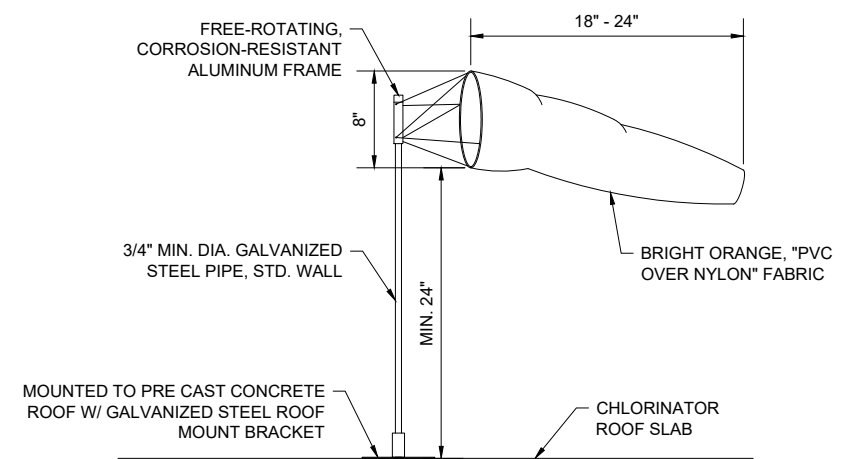

WIND SOCK DETAIL
NOT TO SCALE

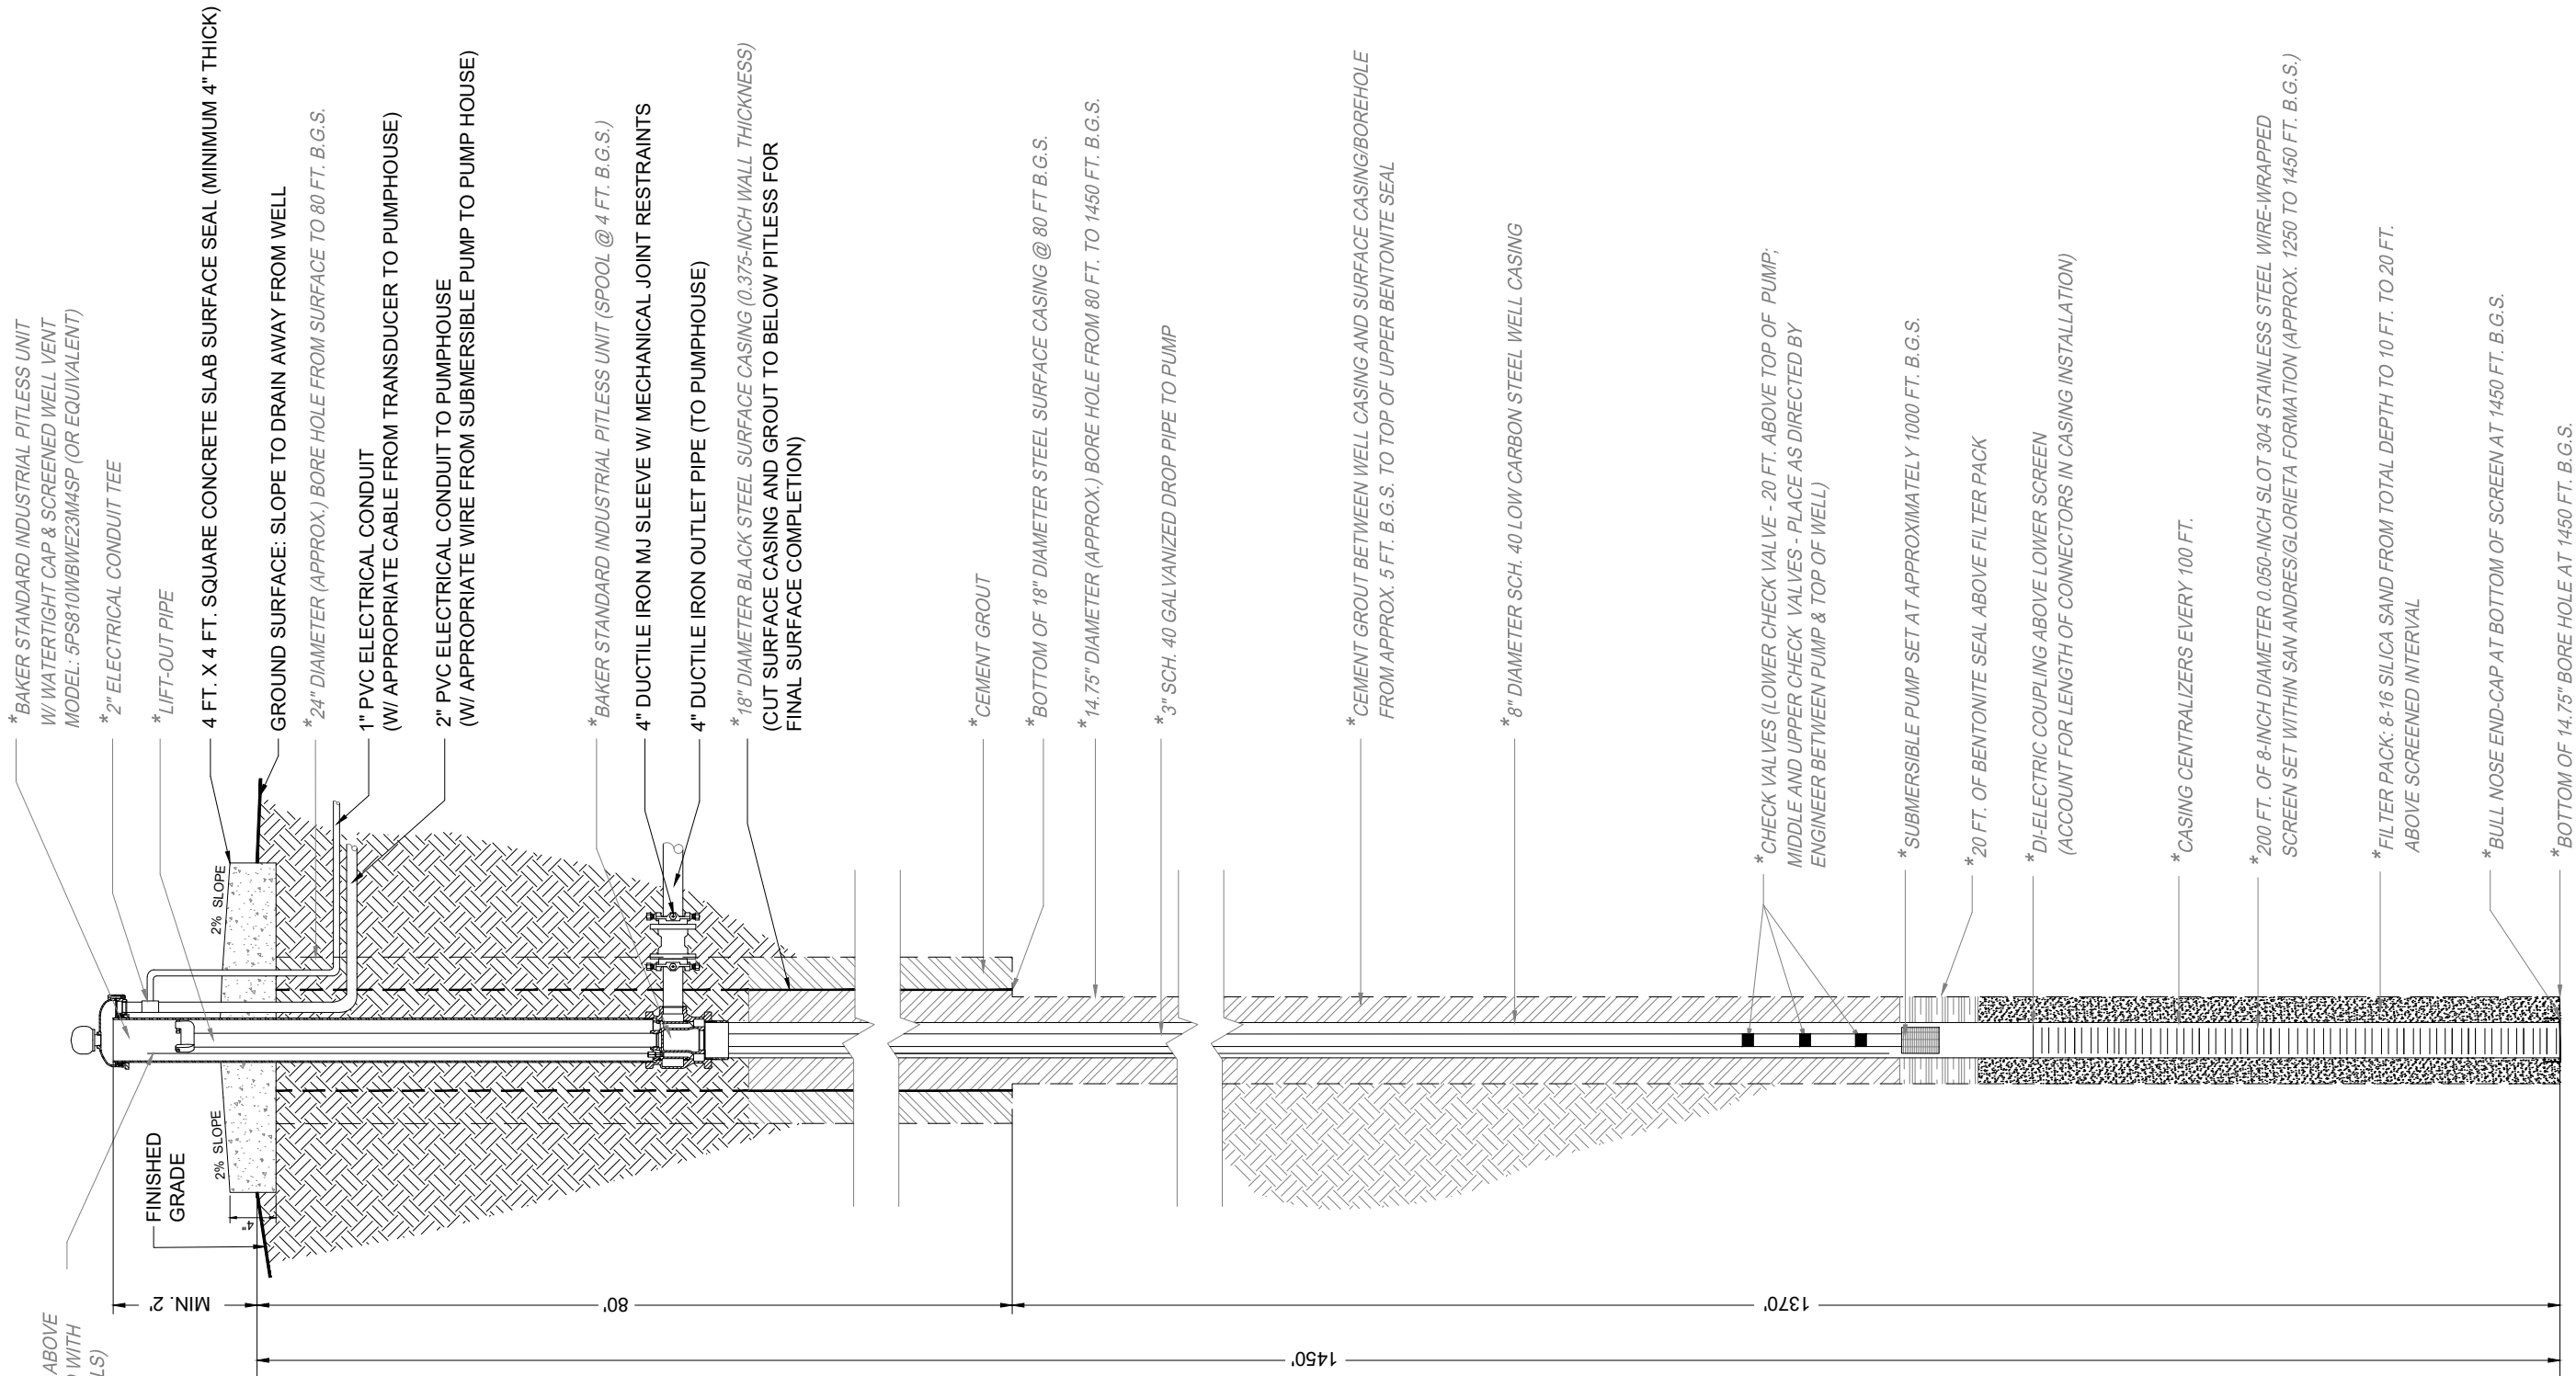

NOTES:

1. DIAGRAM NOT TO SCALE
2. ITEMS MARKED WITH AN ASTERISK * ARE NOT INCLUDED IN THIS PHASE OF THE PROJECT. THESE ITEMS ARE EXISTING.
3. ADDITIONAL REQUIREMENTS FOR INSTALLATION OF PUMP AND OTHER APPURTENANCES, INCLUDING TERMINATION DOWNHOLE AND AT SURFACE, ARE PROVIDED ON SHEET DT-13.

THIS DRAWING IS INCOMPLETE AND NOT TO BE USED FOR CONSTRUCTION UNLESS IT IS STAMPED, SIGNED AND DATED		
Designed TTT	Drawn AAV	Checked JMG
Date: March 2021		
Scale: Horiz: N/A Vert: N/A		
Project No: 6922883		

Sheet:
DT-11

FINAL DESIGN
FOR REVIEW


THE NAVAJO NATION
McKINLEY COUNTY, NEW MEXICO
THOREAU BACA WELL CONNECTION
SECTION 19, T. 14 N., R. 13 W.
THOREAU WELL DESIGN DETAIL






SOUDER, MILLER & ASSOCIATES
Engineering • Environmental • Geomatics
Serving the Southwest & Rocky Mountains
5454 Venice Avenue NE, Suite D
Albuquerque, NM 87113
Phone (505) 299-0942 Toll-Free (877) 299-0942 Fax (505) 293-3400
www.soudermiller.com

Rev.#	Date	Description	By	Chkd

P:\BACA\Previt (6922883)\BACA Thoreau Well Connection\CAD\DWG\6922883-Thoreau Well Conn Fence Details.dwg
3/4/2021 1:52:23 PM jmg

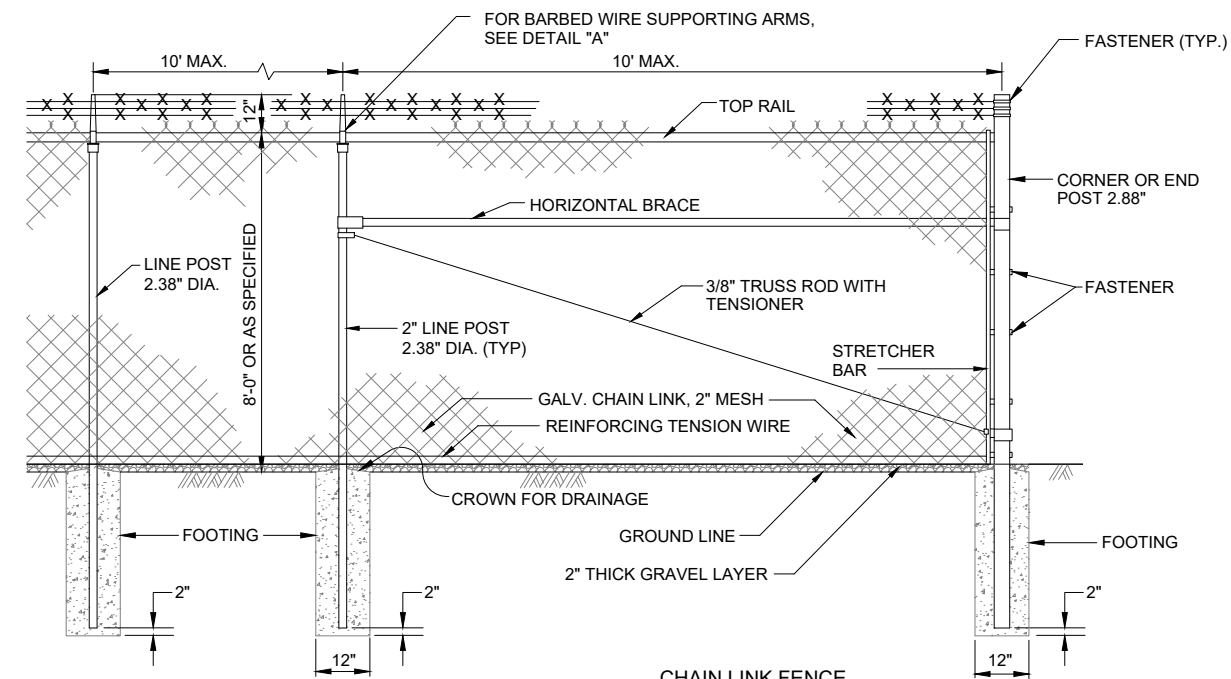


- NOTES:
1. AT BROW CROSSING, EMBED ON 6" CENTERS, 4-11/2" x 24" GALVANIZED RODS WITH 2" HOOKED END INTO BROW DITCH CONCRETE. EXPOSED END OF ROD SHALL BE WOVEN INTO FENCE FABRIC.
 2. IMBED BOTTOM OF FABRIC MIN. 1" INTO THE 2" THICK GRAVEL LAYER.

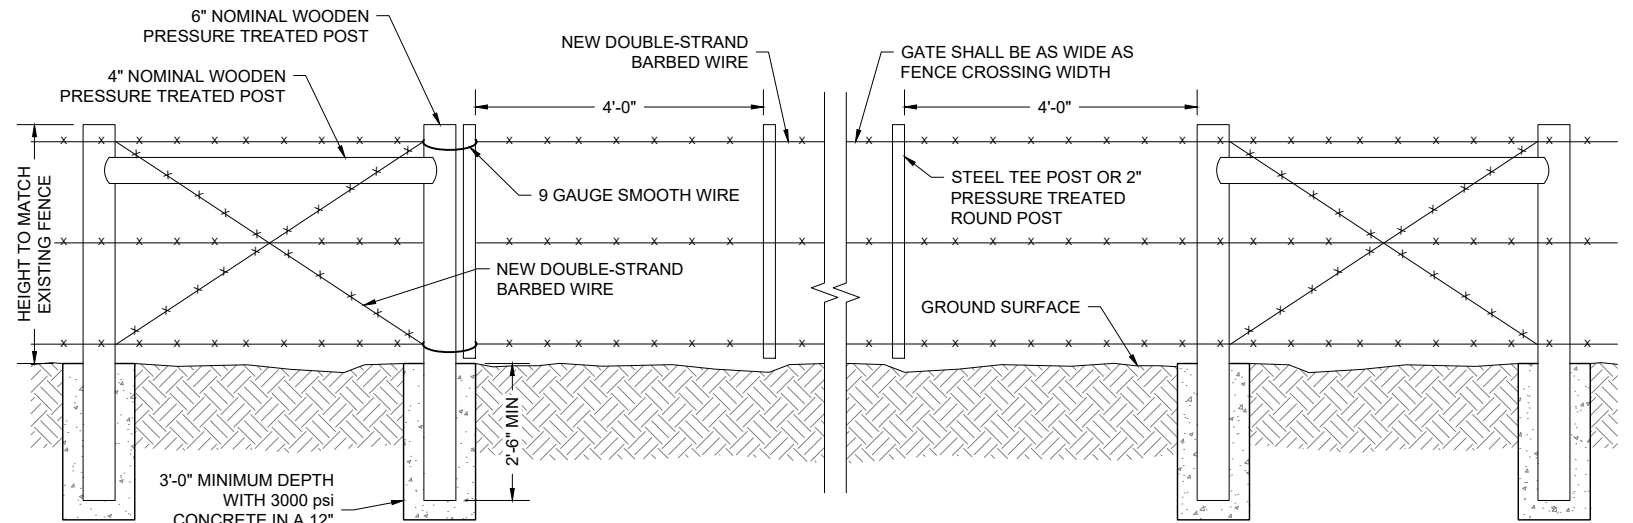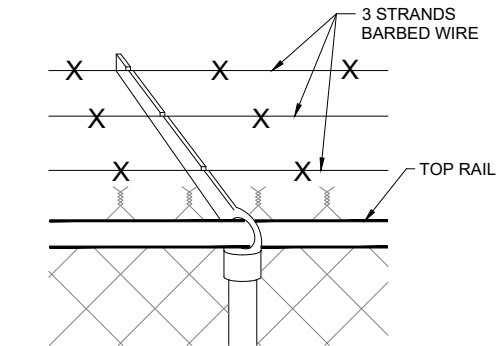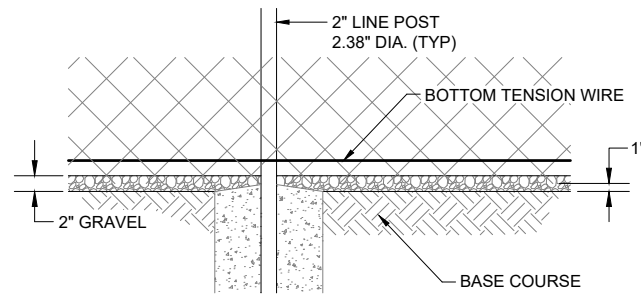

GATE POST					
GATE LEAF WIDTH	GATE POST (OD)	FABRIC HEIGHT	"A" DIAM	"B" DEPTH	"C" POST EMBED.
10'	4"	8'	16"	56"	54"


LINE AND TERMINAL POSTS				
FABRIC HEIGHT	TYPE POST	"A" DIAM	"B" DEPTH	"C" POST EMBED.
8'-0"	LINE	12"	38"	36"
	TERMINAL	12"	38"	36"

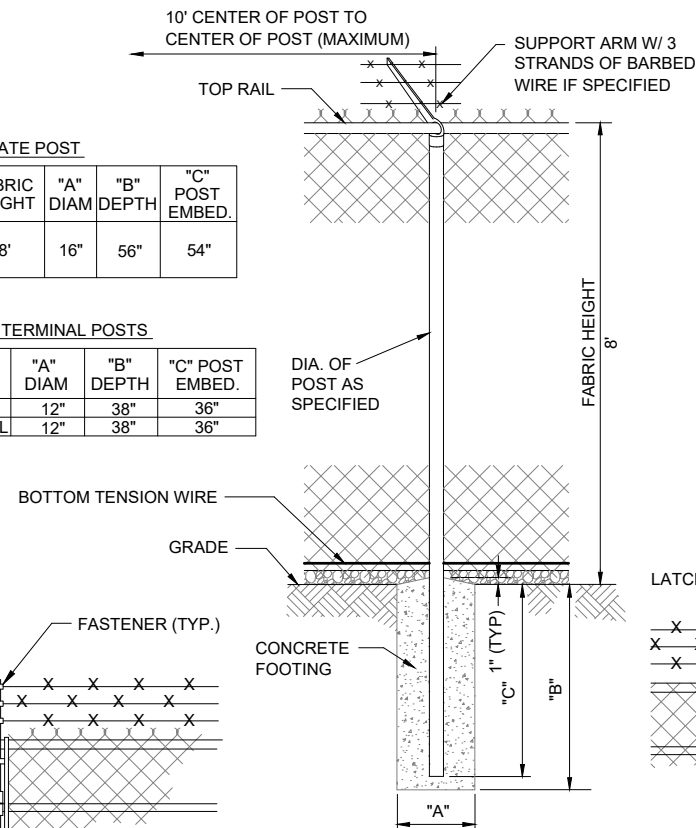


CHAIN LINK FENCE FOUNDATION
NOT TO SCALE

NOTES:


1. COMMON LOCKS SHALL BE PROVIDED FOR ALL FENCE GATES
2. TERMINAL POSTS INCLUDE END, CORNER, AND PULL POSTS

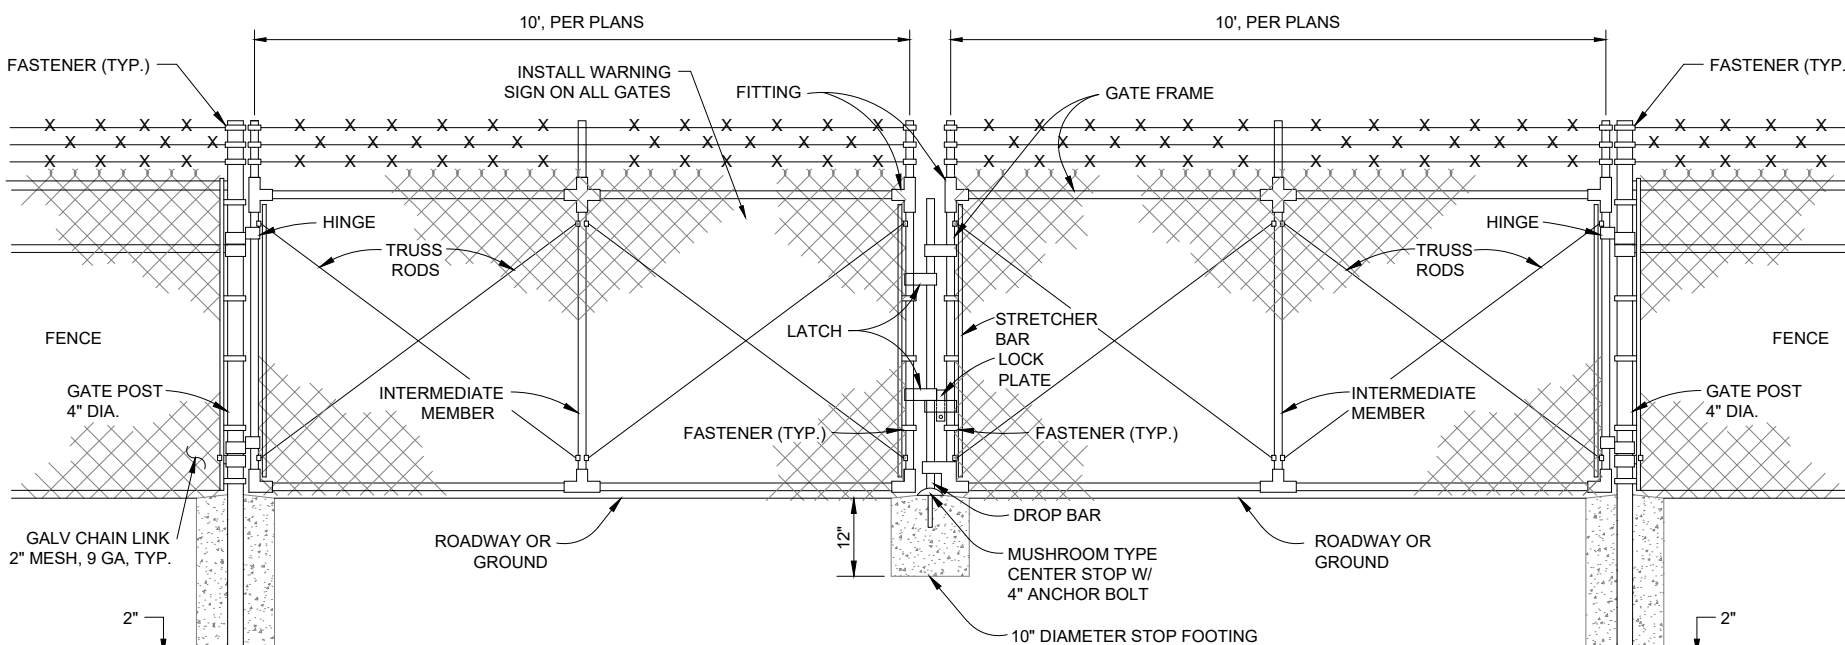


20' DOUBLE SWINGING VEHICLE GATE
NOT TO SCALE

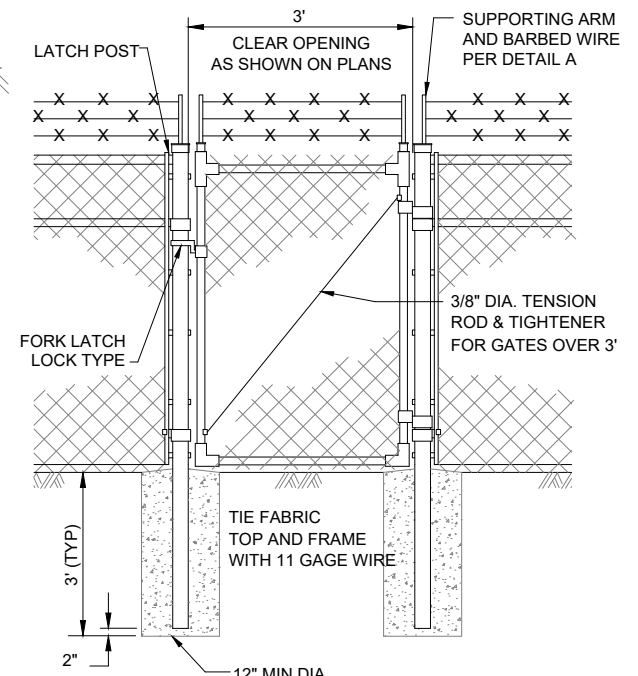


PEDESTRIAN GATE
NOT TO SCALE

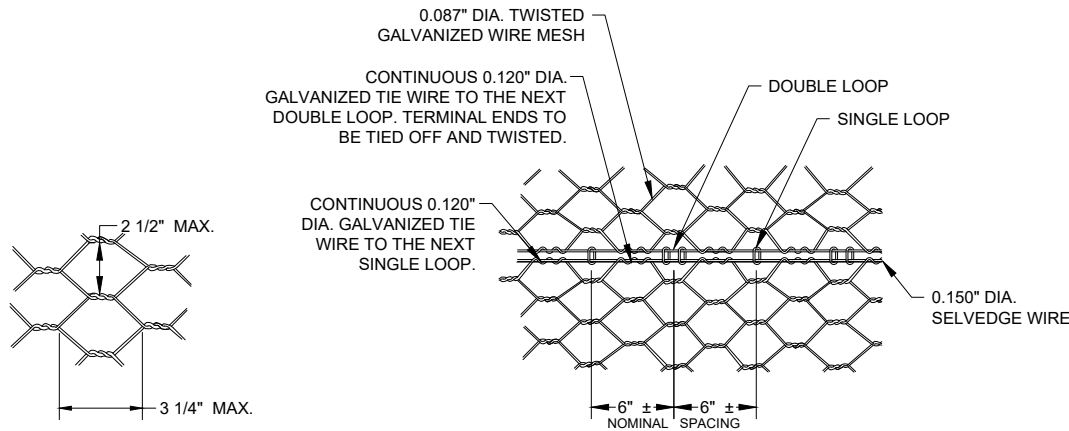


TWISTED MESH MATTRESS
NOT TO SCALE

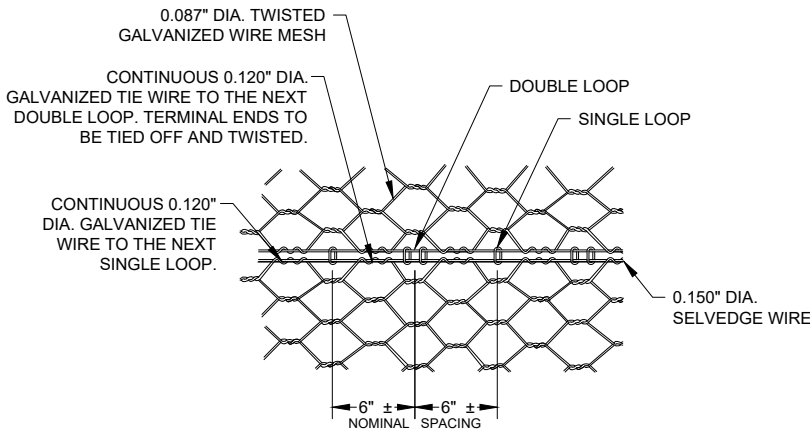


STANDARD JOINT CONNECTION DETAIL
NOT TO SCALE

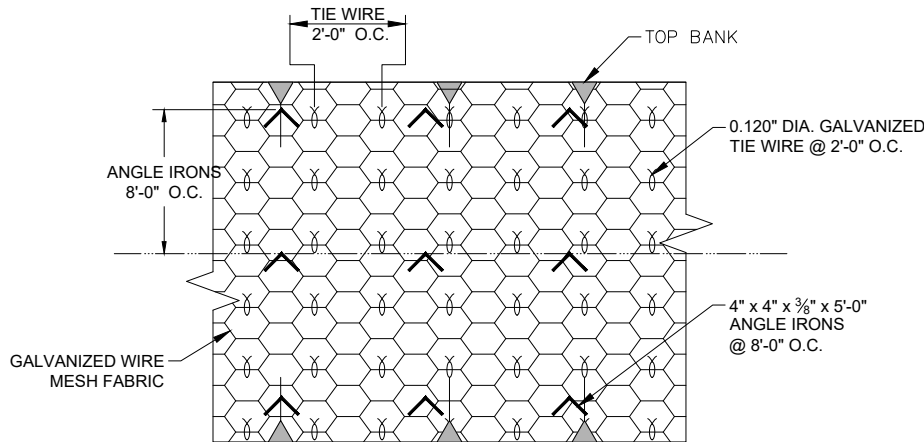


TYP. 12" RIP-RAP CAGE & ANCHORING
NOT TO SCALE

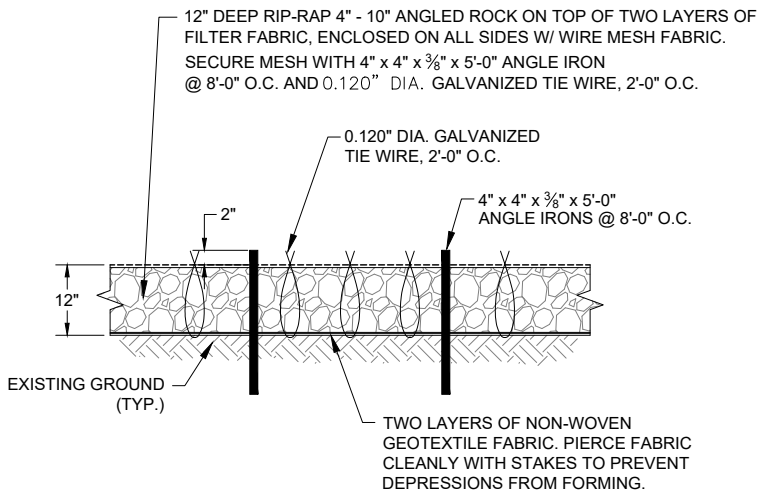

TYPICAL 12" RIP-RAP DETAIL
NOT TO SCALE

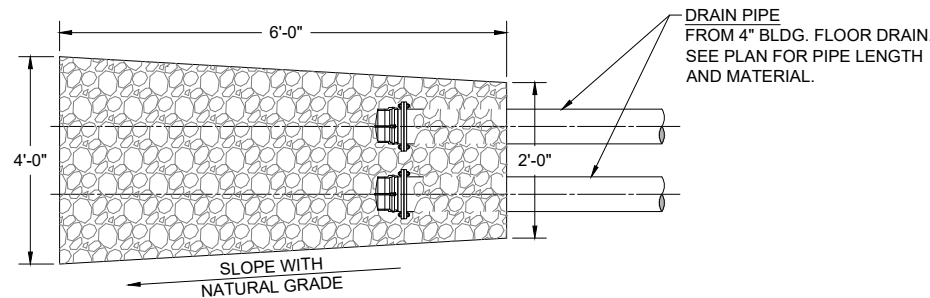

PLAN VIEW

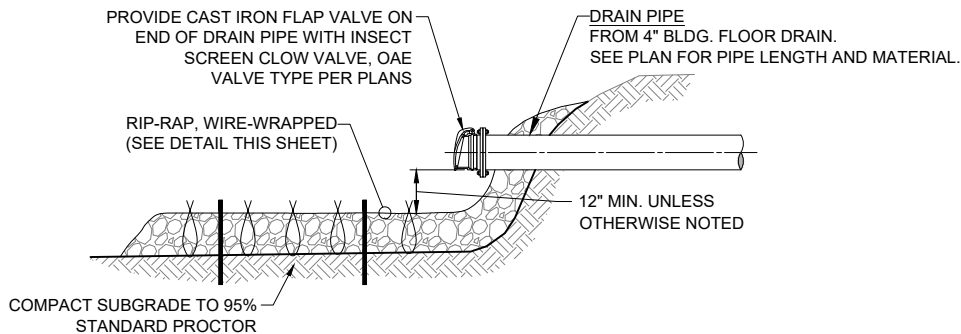

ELEVATION VIEW

TYPICAL SPLASH PAD DETAIL
NOT TO SCALE

P:\0-Baca-Prewitt (6022883)\Baca Thoreau Well Connection\CAD\DWG\6022883-Thoreau Well Conn Details.dwg
3/4/2021 1:52:30 PM gaw

Rev #	Date	Description	By	Chkd



SOUDER, MILLER & ASSOCIATES
Engineering • Environmental • Geomatics
Serving the Southwest & Rocky Mountains
5454 Venice Avenue NE, Suite D
Albuquerque, NM 87113
Phone (505) 299-0942 Toll-Free (877) 299-0942 Fax (505) 293-3400
www.soudermiller.com

McKINLEY COUNTY, NEW MEXICO

THE NAVAJO NATION

THOREAU BACA WELL CONNECTION
SECTION 19, T. 14 N., R. 13 W.
EROSION CONTROL DETAILS

FINAL DESIGN FOR REVIEW

THIS DRAWING IS INCOMPLETE AND NOT TO BE USED FOR CONSTRUCTION UNLESS IT IS STAMPED, SIGNED AND DATED


Designed TTT	Drawn AAV	Checked JMG
-----------------	--------------	----------------

Date: **March 2021**





Scale: Horiz: N/A
Vert: N/A

Project No: 6922883

Sheet: **DT-15**





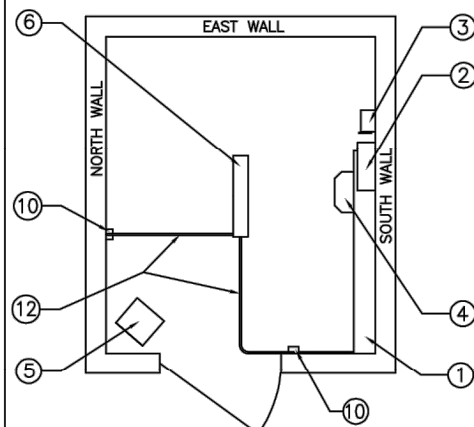


CONTROL ROOM

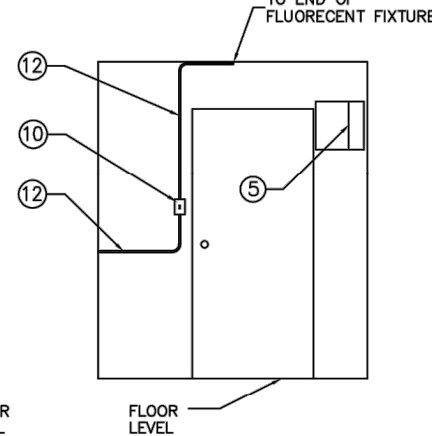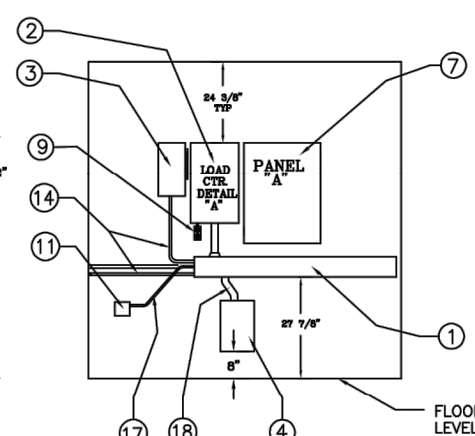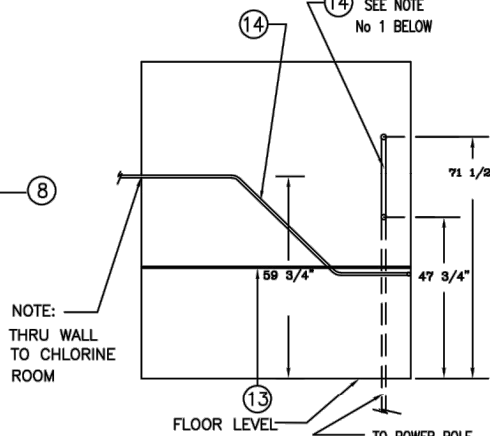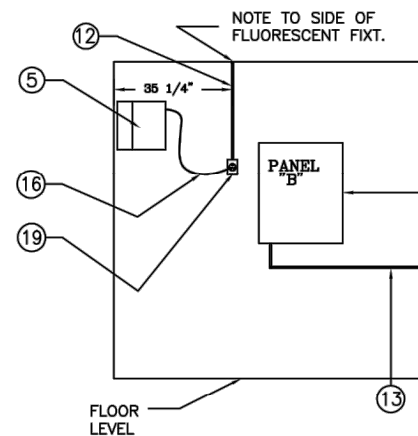

BILL OF MATERIAL CONTROL ROOM

ITEM	DESCRIPTION	QTY.	BRAND, MODEL, SIZE
1	GUTTER	1	6 x 60" x 6-3/8
2	LOAD CENTER W/100 AMP MAIN BREAKER	1	SQUARE D Q 018M 100 RB 22-1/8 x 14-3/8 x 5-1/4
3	DISC SW W/HANDLE W/15-30R FUSES	1	SQUARE D H 361 NRB 15-1/8 x 6-3/8 x 4-1/4
4	TRANSFORMER	1	ACME # T253517-3S 15 x 12 x 12 15KVA, 3PH, 460/240-120 VAC
5	HEATER, 220V, 4000 WATT	1	DAYTON # 3J652 11 x 10-1/2 x 9-3/4
6	FLUORESCENT LIGHT	1	4-1/2" W x 48" LONG
7	PROPOSED PANEL "A"	1	HONEYWELL # L404B-1353 4-1/2 x 3 x 2
8	PROPOSED PANEL "B"	1	SAGINAW # SCE-362410LP 36H x 24W x 10D NEMA 12
9	DUPLEX RECPT - 120V	1	4-1/2 x 3 x 2
10	LIGHT SWITCH	1	4-1/2 x 3 x 2
11	PRESSURE SWITCH, DPDT	1	HONEYWELL # L404B-1353 4-1/2 x 3 x 2
12	1/2" RIDGID CONDUIT	As Req	X
13	3/4" RIDGID CONDUIT	As Req	X
14	1" RIDGID CONDUIT	As Req	X
15	2" RIDGID CONDUIT	As Req	X
16	# 14/3 SJT CORD	As Req	X
17	1/2" SEALTITE	As Req	X
18	2" SEALTITE	As Req	X
19	SINGLE RECPT - 220V	1	4-1/2 x 3 x 2

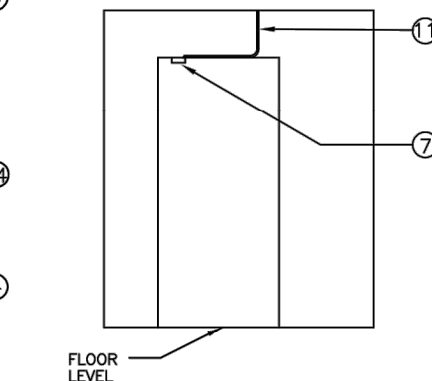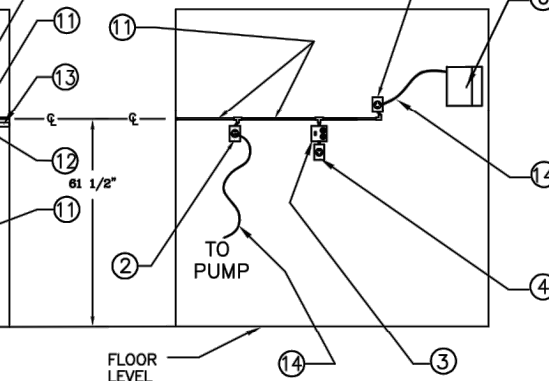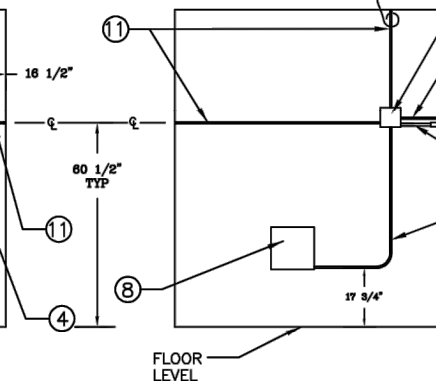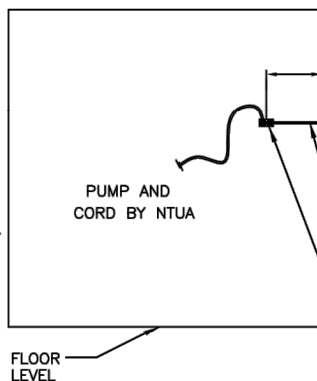
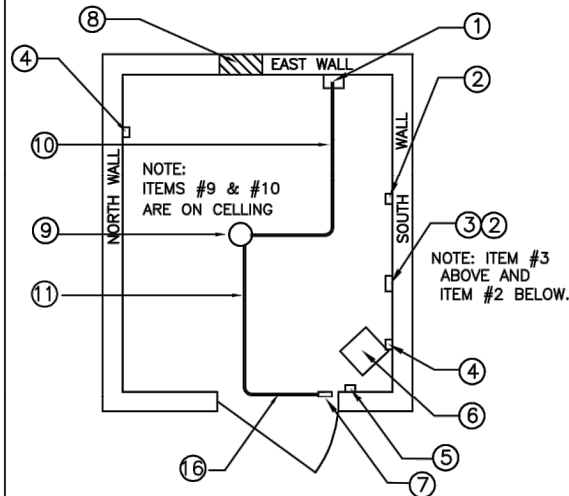


BILL OF MATERIAL CHLORINE ROOM

ITEM	DESCRIPTION	QTY.	BRAND, MODEL, SIZE
1	JCT BOX	1	6 x 6 x 4
2	ONE GANG REC. BOX, 220V	1	4-1/2 x 3 x 2
3	TWO GANG DUP RECP W/SP SW	1	4-1/2 x 4-1/2 x 2
4	ONE GANG RECP BOX, 120V	1	4-1/2 x 3 x 2
5	ONE GANG SW BOX, S/P	1	4-1/2 x 3 x 2
6	HEATER, 220V	1	DAYTON # 3UGS2 11 x 10-1/2 x 9-3/4
7	DOOR SWITCH (LIMIT) FOR EXHAUST FAN	1	CUTLER HAMMER # E50 ARH/E50 KL25 4 x 1-1/2 x 2
8	EXHAUST FAN, (BY CUSTOMER)	1	12-1/2 x 12-3/4 x THRU WALL
9	VAPOR TITE LIGH FIXT, 100W	1	X
10	1/2" RIDGID CONDUIT	As Req	X
11	3/4" RIDGID CONDUIT	As Req	X
12	1" RIDGID CONDUIT	As Req	X
13	1" SEALOFF (To Ctrl Room)	As Req	X
14	#16/3 S/O CORD	As Req	X
15	# 14/3 SJT CORD	As Req	X
16	1/2" SEALTITE	As Req	X

LOAD CENTER DETAIL "A"

LOAD CENTER CIRCUITS, BREAKER LOCATION & BKR/CAT No.							
SPACE No.	BREAKER FOR	AMP	POLES	SPACE No.	BREAKER FOR	AMP	POLES
1	PUMP CONTRL	00 115	SP	2	BOOSTER		
3	CONTROL RM LIGHTS	00 115	SP	4	CHEMICAL	00 315	3P
5	CHLORINE RM LIGHTS	00 115	SP	6	PUMPS		
7	CONTROL ROOM			8	CHLORINE ROOM		
9	HEATER	00 215	DP	10	HEATER	00 215	DP
11	RECEPTACLE - 120 V	00 115	SP	12	SPACE		
13	SPACE			14	SPACE		
15	SPACE			16	SPACE		

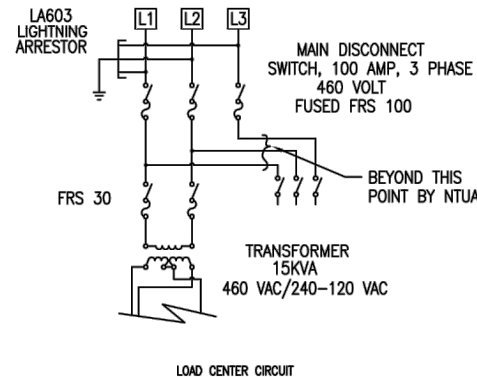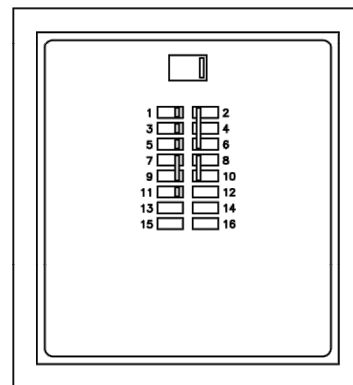

SMA: LAYOUT IS TYPICAL. COORDINATE
ORIENTATION OF SITE AND BUILDING
ELECTRICAL IN FIELD. SEE SHEET C-4 FOR
PRELIMINARY SITE ELECTRICAL LAYOUT.

BY	DATE	DESCRIPTION	BY
U.S. DEPARTMENT OF HEALTH AND HUMAN SERVICES PUBLIC HEALTH SERVICE INDIAN HEALTH SERVICE NAVAJO NATION			
PUMP HOUSE LAYOUT			
PUBLIC LAW 86-121 OFFICE OF ENVIRONMENTAL HEALTH AND ENGINEERING NAVAJO ACD INDIAN HEALTH SERVICE			
DRAWN BY: PUMCAD	CHECKED BY: M.N.	SURVEYED BY:	AUTOCAD
DATE 9/19/97	DATE 1/18/98	DATE:	DRAWING
FARMINGTON FIELD OFFICE FARMINGTON, NEW MEXICO	FILENAME: CARSON PUMP HSES.dwg UPDATED: 1/18/98	SHEET 1 OF 2 TOTAL SHEETS	

PUMP HOUSE LAYOUT

PUBLIC LAW 86-121
OFFICE OF ENVIRONMENTAL HEALTH AND ENGINEERING
NAVAJO AREA INDIAN HEALTH SERVICE

DRAWN BY: PLUCAD DATE: 9/19/97		CHECKED BY: M.N. DATE: 1/16/98		SURVEYED BY: DATE:		AUTOCAD DRAWING	
FARMINGTON FIELD OFFICE FARMINGTON, NEW MEXICO			FILENAME: CARSON PUMP BSES.dwg UPDATED: 1/16/98		SHEET 1 OF 2 TOTAL SHEETS		

SOUDER, MILLER & ASSOCIATES
Engineering • Environmental • Geomatics
Serving the Southwest & Rocky Mountains
5454 Venice Avenue NE, Suite D
Albuquerque, NM 87113
Phone (505) 299-0942 Toll-Free (877) 299-0942 Fax (505) 293-3450
www.soudermiller.com

THOREAU BACA WELL CONNECTION
SECTION 19, T. 14 N., R. 13 W.
PUMP HOUSE LAYOUT (1 OF 2)

STANDARD
DRAWING

THIS DRAWING IS INCOMPLETE
AND NOT TO BE USED FOR
CONSTRUCTION UNLESS IT IS
STAMPED, SIGNED AND DATED


Designed TTT	Drawn AAV	Checked JMG
-----------------	--------------	----------------

Date: March 2021


Scale: Horiz: N/A

Project No: 6922883

Sheet: E-1

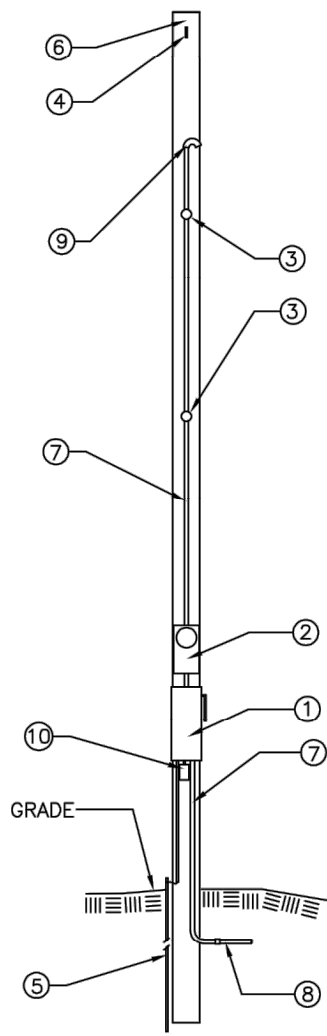

POWER POLE

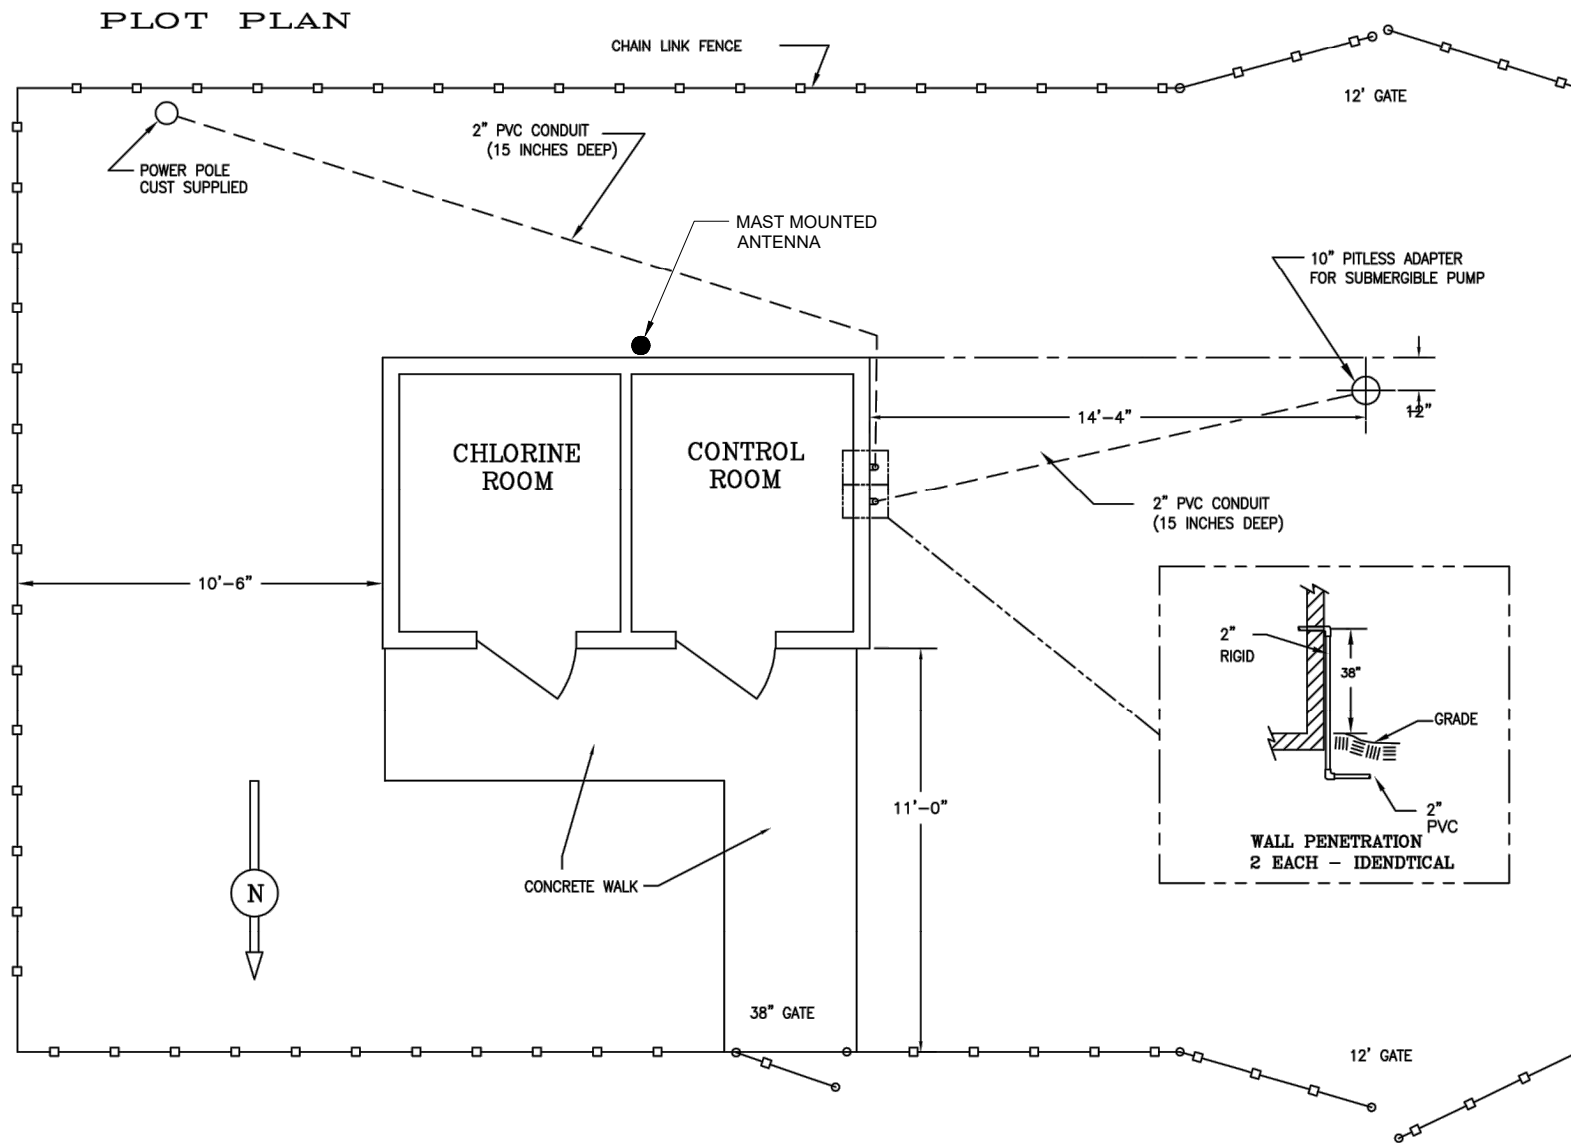

BILL OF MATERIAL POWER POLE			
ITEM	DESCRIPTION	QTY.	BRAND, MODEL, SIZE
1	R/T DISCONNECT FRS-100R W/FUSES	1	SQUARE D 100 AMP # 361 NRB 15-1/8 x 6-3/8 x 4-1/4
2	METER SOCKET, 7 TERM, 3 PHASE	1	DURHAM # R6821-7N-N 22-1/8 x 14-3/8 x 5-1/4
3	STAND OFFS	1	15-1/8 x 6-3/8 x 4-1/4
4	EYEBOLT	1	15 x 12 x 12
5	GROUND ROD	1	5/8 DIA x 10 FT LG
6	POLE	1	8 in DIA x 25 ft LONG BY CUST
7	2" RIDGID CONDUIT	As Req	
8	2" PVC	As Req	
9	ENTRANCE HEAD	1	
10	LIGHTNING ARRESTOR	1	DELTA LIGHTNING ARRESTOR Co. # LA803

SMA: LAYOUT IS TYPICAL. COORDINATE
ORIENTATION OF SITE AND BUILDING
ELECTRICAL IN FIELD. SEE SHEET C-4 FOR
PRELIMINARY SITE ELECTRICAL LAYOUT.

REVISION	DATE	DESCRIPTION	BY
U.S. DEPARTMENT OF HEALTH AND HUMAN SERVICES PUBLIC HEALTH SERVICE INDIAN HEALTH SERVICE NAVAJO NATION			
PUMP HOUSE LAYOUT			
PUBLIC LAW 86-121 OFFICE OF ENVIRONMENTAL HEALTH AND ENGINEERING NAVAJO AREA INDIAN HEALTH SERVICE			
DRAWN BY: PUMCB	CHECKED BY: M.N.	SURVEYED BY:	AUTOCAD
DATE: 9/19/97	DATE: 1/16/98	DATE:	DRAWING
FARMINGTON FIELD OFFICE FARMINGTON, NEW MEXICO	FILENAME: CARBON PUMP BSES.dwg UPDATED: 1/16/98	SHEET 2 OF 2 TOTAL SHEETS	

SOUDER, MILLER & ASSOCIATES
Engineering • Environmental • Geomatics
Serving the Southwest & Rocky Mountains
5454 Venice Avenue NE, Suite D
Albuquerque, NM 87113
Phone (505) 299-0942 Toll-Free (877) 299-0942 Fax (505) 293-3430
www.soudermiller.com

THE NAVAJO NATION
McKINLEY COUNTY, NEW MEXICO
THOREAU BACA WELL CONNECTION
SECTION 19, T. 14 N., R. 13 W.
PUMP HOUSE LAYOUT (2 OF 2)

STANDARD
DRAWING

THIS DRAWING IS INCOMPLETE
AND NOT TO BE USED FOR
CONSTRUCTION UNLESS IT IS
STAMPED, SIGNED AND DATED

Designed TTT Drawn AAV Checked JMG

DATE: March 2021

Scale: Horiz: N/A
Vert: N/A

Project No: 6922883

Sheet: E-2

P:\BACA-Prewitt (6922883)\BACA Thoreau Well Connection\CAD\DWG\6922883-Thoreau Well Conn Electrical.dwg
3/4/2021 1:55:41 PM jmg

NAVAJO TRIBAL UTILITY AUTHORITY PUMP CONTROL PANEL LAYOUT



SOFT START PUMP PANEL

SCHEDULE OF DRAWINGS			
SHEET	FILENAME	TITLE	NOTES
1	SS_CV	COVERSHEET	SCHEDULE OF DRAWINGS
2	SS_LOG	LOGIC WIRING	WIRING
3	SS_BP_1*HP	GEN. ARRANGEMENT	BACKPLANE LAYOUT

NO.	DATE	DESCRIPTION	BY
 NAVAJO TRIBAL UTILITY AUTHORITY			
SCALE	NONE	REVISION	BY DATE
DATE			
APP'D			
FILE 3 PHASE - SOFT START PUMP PANEL		SHEET 1 OF 3	
COVER SHEET			

THE NAVAJO NATION

McKINLEY COUNTY, NEW MEXICO

SOUDER, MILLER & ASSOCIATES

Engineering • Environmental • Geomatics
Serving the Southwest & Rocky Mountains
5454 Venice Avenue NE, Suite D
Albuquerque, NM 87113
Phone (505) 299-0942 Toll-Free (877) 299-0942 Fax (505) 293-3430
www.soudermiller.com

THOREAU BACA WELL CONNECTION

SECTION 19, T. 14 N., R. 13 W.

SOFT START PUMP PANEL (1 OF 3)

STANDARD DRAWING

THIS DRAWING IS INCOMPLETE AND NOT TO BE USED FOR CONSTRUCTION UNLESS IT IS STAMPED, SIGNED AND DATED

Designed
TTT

Drawn
AAV

Checked
JMG

Date:

March 2021

Scale:

Horiz: N/A
Vert: N/A


Project No:

6922883

Sheet:

E-3


© Copyright 2020 Souder, Miller & Associates - All Rights Reserved

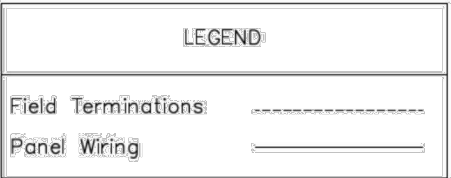

STANDARD
DRAWING

Sheet: E-4

P:\Bac-Prewitt (6922883)\Bac-Prewitt Thoreau Well Connection\CAD\DWG\6922883-Thoreau Well Conn Electrical.dwg
3/4/2021 1:55:37 PM gaw

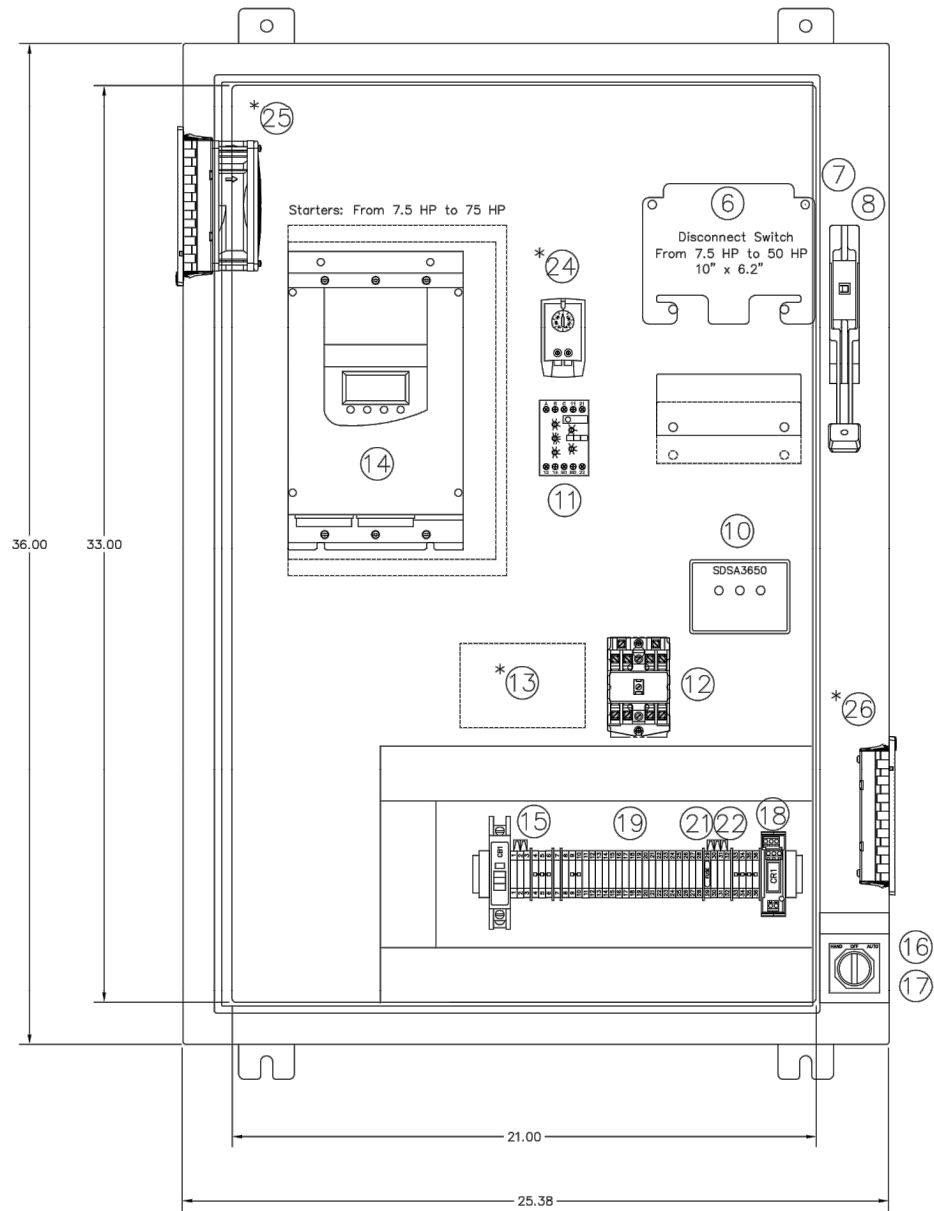

BILL OF MATERIALS				
ITEM	QTY	PART NO.	DESCRIPTION	MFG
1	1	A-36SA2610LPPL	SINGLE DOOR TYPE 12 ENCLOSURE	HOFFMAN
2	1	A-36P24	BACKPLANE	HOFFMAN
3	1	F2X4LG6	2X4 WIRING DUCT	PANDUIT
4	1	C2LG6	2" DUCT COVER	PANDUIT
5	1	1492DR6	EXTENDED DIN RAIL	ALLEN BRADLEY
6	1	REFER TO TABLE 1	DISCONNECT	SQUARE D
7	1	9422A1	HANDLE	SQUARE D
8	1	9422 TDK-2	DOOR MOUNT	SQUARE D
9	3	REFER TO TABLE 1	480V DISCONNECT FUSE	BUSSMAN
10	1	SDSA3650	SECONDARY SURGE ARRESTER	SQUARE D
11	1	D65VMLS480	PHASE MONITOR	EATON
12	1	8501XMO40V02	8501 TYPE X INDUSTRIAL CONTROL RELAY	SQUARE D
13*	1	1500-G-L1-S7	INDUCTION CONTROL RELAY	B/W CONTROL
14	1	REFER TO TABLE 1	ALTISTART 48	SQUARE D
15	1	QOU115	15A CIRCUIT BREAKER	SQUARE D
16	1	9001KS43BH2	SELECTOR SWITCH	SQUARE D
17	1	9001KN160WP	HOA LEGEND PLATE	SQUARE D
18	1	UMK 22 REL 24	RELAY MODULE, DPDT	PHOENIX CONTACT
19	32	UK5 N	UK5 N TERMINALS	PHOENIX CONTACT
20	1	USLKG5	GROUND TERMINAL	PHOENIX CONTACT
21	1	UK4TG	FUSE TERMINAL BASE	PHOENIX CONTACT
22	1	ST-SILA250UK4	FUSE PLUG W/FUSE	PHOENIX CONTACT
23	1	FB10-6 #0201184	FIXED BRIDGE	PHOENIX CONTACT
24*	1	FLZ 530	THERMOSTAT	PFANNENBERG
25*	1	PF 22000	FAN FILTER KIT	PFANNENBERG
26*	1	PFA 20000	LOUVER FILTER KIT	PFANNENBERG

13* - WILL BE USED IF THERE IS NO SUBMERSIBLE TRANSMITTER AVAILABLE.
24*,25*,26* - WILL BE USED ON ALL INDOOR APPLICATIONS..

TABLE 1 - ADDITIONAL PART NUMBERS				
STARTER	APPLICATION	ALTISTART 48	DISCONNECT	DISCONNECT FUSE
10 HP	7.5 HP	ATS48D17Y	TCF331	FRS-R-20
15 HP	10 HP	ATS48D22Y	TCF331	FRS-R-30
20 HP	15 HP	ATS48D32Y	TDF631	FRS-R-40
25 HP	20 HP	ATS48D38Y	TDF631	FRS-R-45
30 HP	25 HP	ATS48D47Y	TDF631	FRS-R-60
40 HP	30 HP	ATS48D62Y	TEF101	FRS-R-70
50 HP	40 HP	ATS48D75Y	TEF101	FRS-R-90
60 HP	50 HP	ATS48D88Y	TEF101	FRS-R-110

02	12/12	MATERIALS LIST & DWG UPDATES	NTUA
01	07/05	MATERIALS LIST & DWG UPDATES	NTUA
NO.	DATE	DESCRIPTION	BY
NAVAJO TRIBAL UTILITY AUTHORITY			
SCALE:	NONE	REVISIONS	BY DATE
DATE:			
DWG.	DWG.		
APPROV.			
TITLE		SHEET #	
3 PHASE - SOFT START PUMP PANEL 7.5 HP TO 50 HP APPLICATIONS BACKPLANE		SHEET 3 OF 3	

By:
Checked:
Description:
Rev #
Date

SOUDER, MILLER & ASSOCIATES
Engineering • Environmental • Geomatics
Serving the Southwest & Rocky Mountains
5454 Venice Avenue NE, Suite D
Albuquerque, NM 87113
Phone (505) 299-0942 Toll-Free (877) 299-0942 Fax (505) 293-3430
www.soudermiller.com

THE NAVAJO NATION
McKINLEY COUNTY, NEW MEXICO

THOREAU BACA WELL CONNECTION
SECTION 19, T. 14 N., R. 13 W.
SOFT START PUMP PANEL (3 OF 3)

STANDARD
DRAWING

THIS DRAWING IS INCOMPLETE
AND NOT TO BE USED FOR
CONSTRUCTION UNLESS IT IS
STAMPED, SIGNED AND DATED

Designed: TTT Drawn: AAV Checked: JMG

Date: March 2021

Scale: Horiz: N/A
Vert: N/A

Project No: 6922883

Sheet: **E-5**

P:\BACA-Prewitt (6922883)\BACA Thoreau Well Connection\CAD\DWG\6922883-Thoreau Well Conn Electrical.dwg
3/4/2021 1:52:02 PM jmv

NAVAJO TRIBAL UTILITY AUTHORITY
PUMP CONTROL PANEL LAYOUT



PLC CONTROL PANEL

SCHEDULE OF DRAWINGS			
SHEET	FILENAME	TITLE	NOTES
1	PLC_CV	COVERSHEET	SCHEDULE OF DRAWINGS
2	PLC_DIO	DISCRETE I/O	WIRING
3	PLC_AIO	ANALOG I/O	WIRING
4	PLC_PWR	POWER DISTRIBUTION	WIRING
5	PLC_BP	BACKPLANE LAYOUT	BP W/ BOM
5A	PLC_SOP	SWING OUT PANEL	BP W/ BOM
6	PLC_CBL	COMM CABLES PINOUT	

NO.	DATE	DESCRIPTION	BY
 NAVAJO TRIBAL UTILITY AUTHORITY			
SCALE	NONE	REVISION	BY DATE
DATE	12/1/97		
DATE			
DATE			
FILE	PLC CONTROL PANEL COVER SHEET		SHEET 1 OF 6



SMA
Engineering • Environmental • Geomatics
Serving the Southwest & Rocky Mountains
5454 Venice Avenue NE, Suite D
Albuquerque, NM 87113
Phone (505) 299-0942 Toll-Free (877) 299-0942 Fax (505) 293-3430
www.soudermiller.com

SOUDER, MILLER & ASSOCIATES

THE NAVAJO NATION

McKINLEY COUNTY, NEW MEXICO

THOREAU BACA WELL CONNECTION
SECTION 19, T. 14 N., R. 13 W.
PLC CONTROL PANEL (1 OF 6)

STANDARD DRAWING

THIS DRAWING IS INCOMPLETE AND NOT TO BE USED FOR CONSTRUCTION UNLESS IT IS STAMPED, SIGNED AND DATED

Designed TTT	Drawn AAV	Checked JMG
-----------------	--------------	----------------

Date: **March 2021**

Scale: Horiz: N/A
Vert: N/A

Project No: 6922883

Sheet: **E-6**





LEGEND	
Field Terminations	-----
Panel Wiring	_____

The diagram shows a power supply circuit. A transformer labeled TS2 is connected to a 29V source. The secondary winding of the transformer is connected to a diode bridge rectifier. The output of the rectifier is connected to a filter capacitor labeled C1. The other side of the capacitor is connected to a +24V DCC output. The transformer is also connected to a 17V source. The output is connected to a GRND terminal.



THE NAVAJO NATION		MCKINLEY COUNTY, NEW MEXICO	
STANDARD DRAWING THIS DRAWING IS INCOMPLETE AND NOT TO BE USED FOR CONSTRUCTION UNLESS IT IS STAMPED, SIGNED AND DATED		THOREAU BACA WELL CONNECTION SECTION 19, T. 14 N., R. 13 W. PLC CONTROL PANEL (3 OF 6)	
Designed	TTT	Drawn	AAV
Checked	JMG		
Date:		March 2021	
Scale:		Horiz: N/A Vert: N/A	
Project No:		6922883	
Sheet:		E-8	

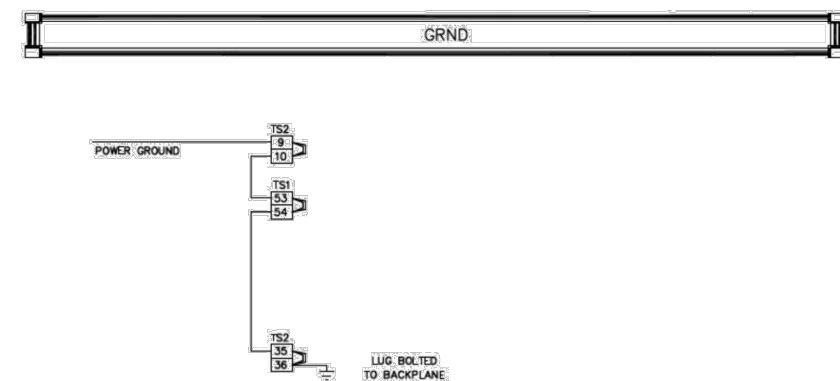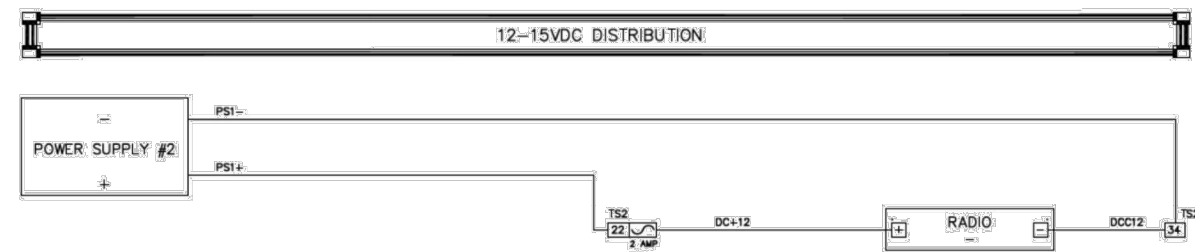



Field Terminations: _____

Panel Wiring: _____

STANDARD
DRAWING

Scale: Horiz: N/A

Sheet: E-9

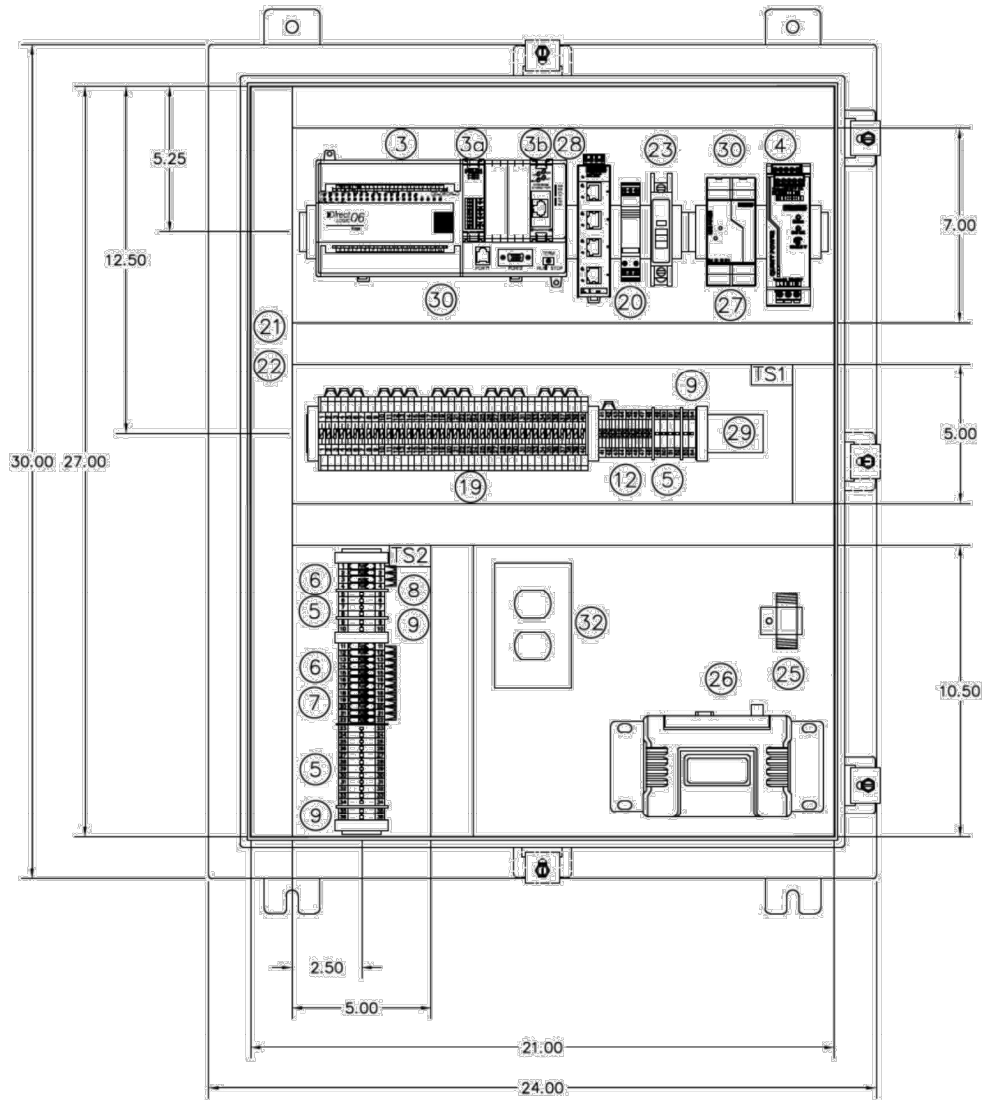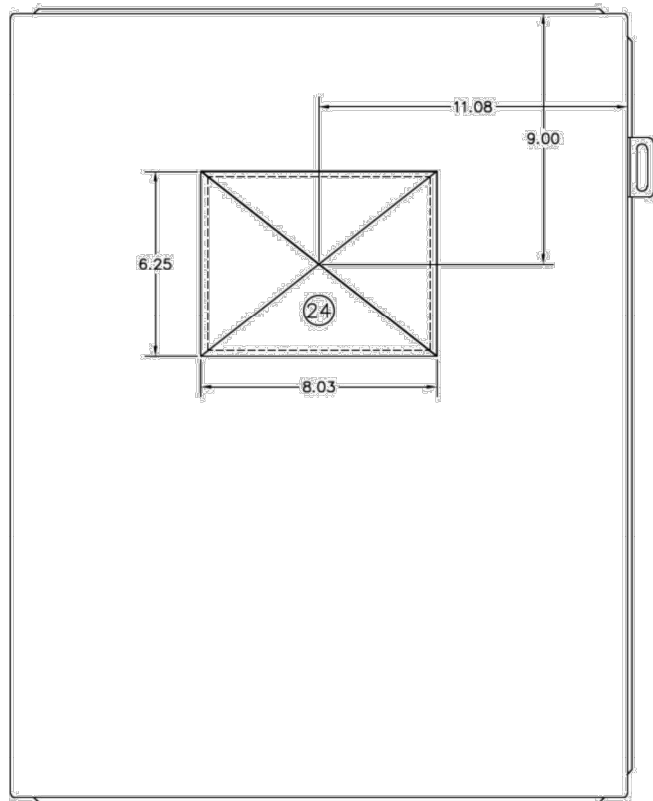

BILL OF MATERIALS			
ITEM	QTY	PART NO.	DESCRIPTION
1	1	A-302410LP	SINGLE DOOR TYPE 12 ENCLOSURE
2	1	A-30P24	BACKPLANE
3	1	D0-06DR-D	DIRECT LOGIC DL-06 PLC
3a	1	F0-04AD-1	ANALOG INPUT MODULE
3b	1	H0-ECOM100	ETHERNET COMM MODULE
4	1	QUINT-PS/1AC/24DC/5	POWER SUPPLY 22.5-28.5V ADJUSTABLE
5	20	UK5 N	UK5 N TERMINALS
6	16	UK4TG	FUSE TERMINAL BASE
7	12	ST-SILE24UK4	FUSE
8	4	ST-SILA250UK4	FUSE
9	6	USUKG5	GROUNDING TERMINAL
10	12	E/NS35N	END CLAMP
11	10	FB10-6 #0201184	FIXED BRIDGE
12	10	EB10-6 #0201139	INSERTION BRIDGE
13	10	D-UK4/10	END COVER
14	10	ATP-UK	PARTITION PLATES
15	3	DP-UKK3/5BK	SLKK5 SPACER PLATE
16	3	D-UKK3/5BK	SLKK5 ENDCOVER
17	8	UK-5/24 DC #2794699	TERMITRAB UKS W/SUPPRESSOR DIODE
18			
19	40	SLKK5-5/24VDC #2794903	TERMITRAB SLKK5 W/VARISTOR 24DC (MOV)
20	1	PT2PE/S120AC	TERMITRAB AC POWER PROTECTION
21	2	E1.5X4LG6	WIRING DUCT
22	2	C1.5LG6	DUCT COVER
23	1	QOU115	CIRCUIT BREAKER
24	1	XBT-GT4330	7.5" GRAPHIC TERMINAL TOUCHSCREEN (MAGELIS)
24a	1	CAT6	ETHERNET PATCH CABLE (4' - BLACK)
25	1	IS-50NX-C2	LIGHTNING ARRESTER
26	1	TransNET	900 MHz RADIO
27	1	SD4	400 MHz RADIO
28	1	MINI-PS-100-240 AC/10-15V ADJUSTABLE	POWER SUPPLY 10-15V ADJUSTABLE
29	1	FL SWITCH SFN-5TX	ETHERNET SWITCH
30	1	1492DR6	EXTENDED DIN RAIL
31	1	1492-DR5	DIN RAIL
32	1	COMM CABLE DRUBGF15	CABLE - PLC TO MODEM (TO LENGTH) DIN RAIL UTILITY BOX

03	11/14	MATERIALS LIST & DWG UPDATES	NTUA
02	12/12	MATERIALS LIST & DWG UPDATES	NTUA
01	01/11	MATERIALS LIST & DWG UPDATES	NTUA
NO.	DATE	DESCRIPTION	BY
NAVAJO TRIBAL UTILITY AUTHORITY			
SCALE: NONE	REVISION:	BY:	DATE:
DATE:			
DATE:			
DATE:			
DATE:			
TITLE: PLC CONTROL PANEL		SHEET 5 OF 6	

SOUDER, MILLER & ASSOCIATES
Engineering • Environmental • Geomatics
Serving the Southwest & Rocky Mountains
5454 Venice Avenue NE, Suite D
Albuquerque, NM 87113
Phone (505) 299-0942 Toll-Free (877) 299-0942 Fax (505) 293-3430
www.soudermiller.com



THE NAVAJO NATION
McKINLEY COUNTY, NEW MEXICO
THOREAU BACA WELL CONNECTION
SECTION 19, T. 14 N., R. 13 W.
PLC CONTROL PANEL (5 OF 6)

STANDARD
DRAWING

THIS DRAWING IS INCOMPLETE
AND NOT TO BE USED FOR
CONSTRUCTION UNLESS IT IS
STAMPED, SIGNED AND DATED

Designed TTT
Drawn AAV
Checked JMG

Date: March 2021
Scale: Horiz: N/A
Vert: N/A
Project No: 6922883
Sheet: E-10

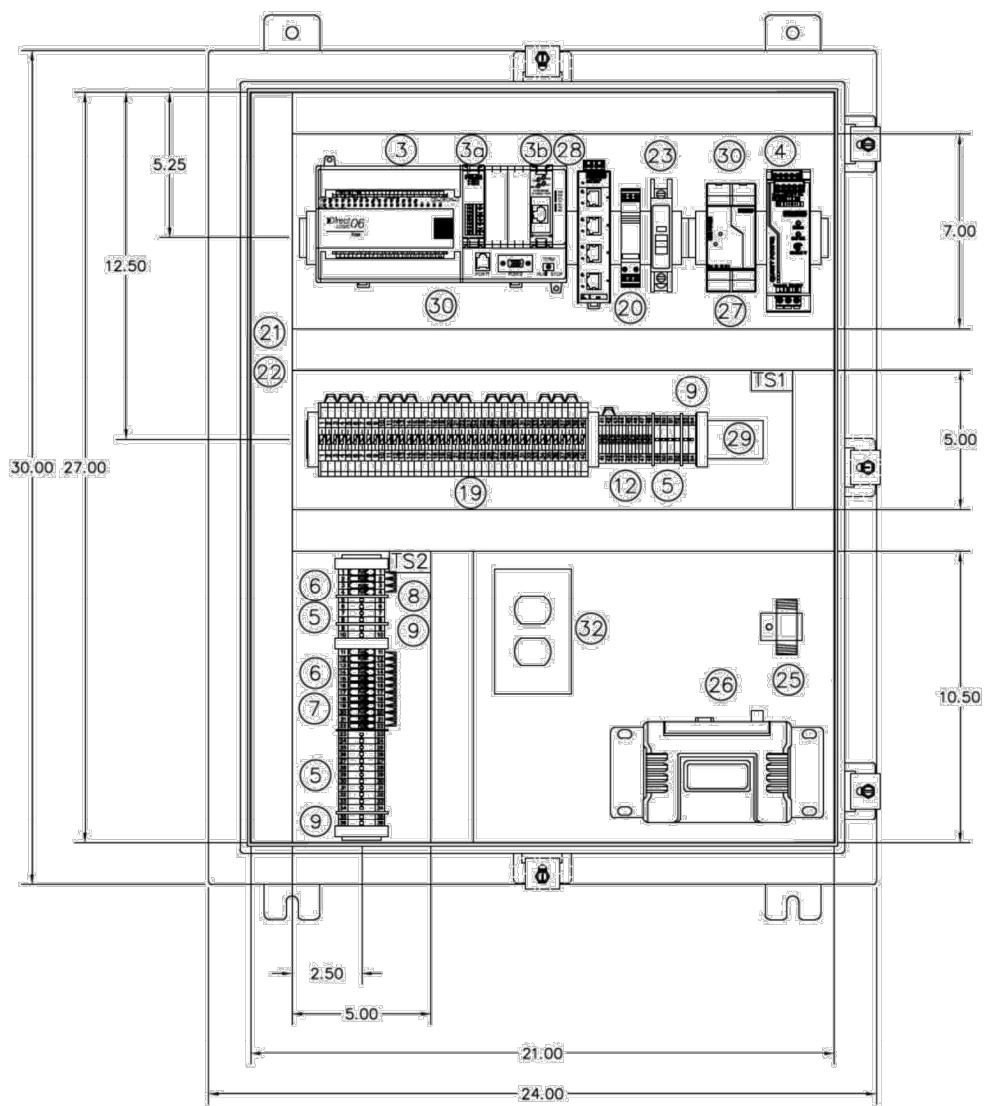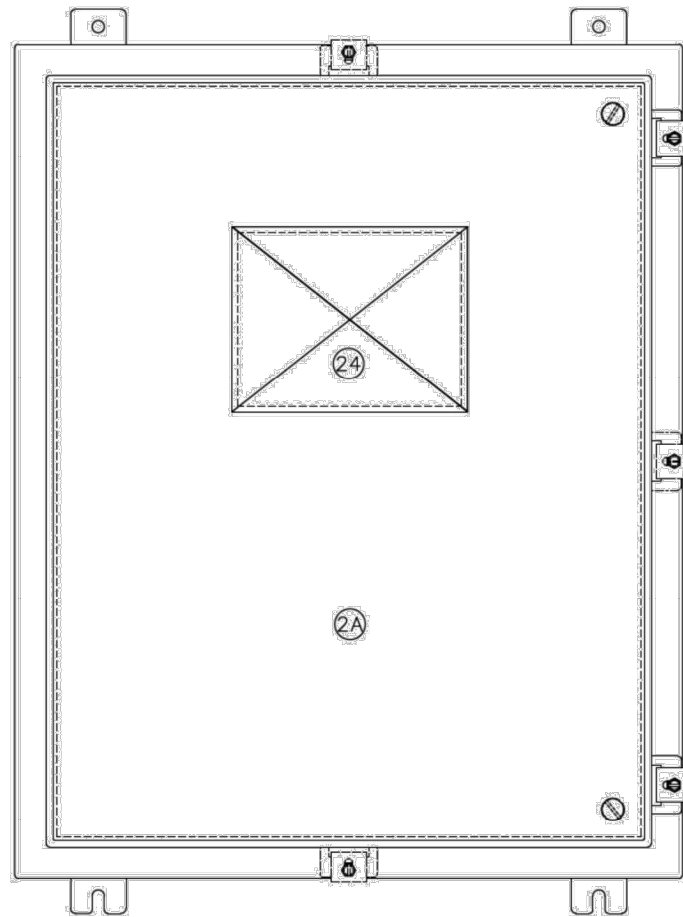

BILL OF MATERIALS			
ITEM	QTY	PART NO.	DESCRIPTION
1	1	A-30H24CLP	SINGLE DOOR TYPE 4 ENCLOSURE
2	1	A-30P24	BACKPLANE
2a	1	A-NADFK	SWNG OUT PANEL KIT
3	1	DO-06DR-D	DIRECT LOGIC DL-06 PLC
3a	1	FO-04AD-1	ANALOG INPUT MODULE
3b	1	HO-ECOM100	ETHERNET COMM MODULE
4	1	QUINT-PS-100	POWER SUPPLY 240AC-24DC-5
5	20	UK5-N	UK5 N TERMINALS
6	16	UK4TG	FUSE TERMINAL BASE
7	12	ST-SLED24UK4	FUSE
8	4	ST-SILU250UK4	FUSE
9	6	USLKG5	GROUNDING TERMINAL
10	12	E/NS35N	END CLAMP
11	10	FB10-6	FIXED BRIDGE
12	10	EB10-6	INSERTION BRIDGE
13	10	D-UK4/10	END COVER
14	10	ATP-UK	PARTITION PLATES
15	3	DP-UKK3/5BK	SLKK5 SPACER PLATE
16	3	D-UKK3/5BK	SLKK5 ENDCOVER
17	8	UK 5/24 DC	TERMITRAB UK5
18	1	#2794699	W/SUPPRESSOR DIODE
19	40	SLKK5 5/24VDC	TERMITRAB SLKK5
20	1	#2794903	W/VARISTOR 24DC (MOV)
21	2	P12PE/S120AC	TERMITRAB AC POWER PROTECTION
22	2	E1.5X4LG6	WIRING DUCT
23	2	C1.5LG6	DUCT COVER
24	1	QOU115	CIRCUIT BREAKER
24a	1	XBT-GT4330	7.5 GRAPHIC TOUCHSCREEN (MAGELUS)
25	1	CAT6	ETHERNET PATCH CABLE (4' - BLACK)
26	1	IS-50NX-C2	LIGHTNING ARRESTER
27	1	TronNET	902 - 1928 MHz RADIO
28	1	SD4	380 - 512 MHz RADIO
29	1	MINI-PS-100-240	POWER SUPPLY 10-15V ADJUSTABLE
30	1	AC/10-15DC/2	ETHERNET SWITCH
31	3	FL SWITCH SFN 5TX	EXTENDED DIN RAIL
32	1	1492DR6	DIN RAIL
33	1	1492-DR5	CABLE - PLC TO MODERN (TO LENGTH)
34	1	COMM CABLE DRUBOF115	DIN RAIL UTILITY BOX

NO.	DATE	DESCRIPTION	BY
03	11/14	MATERIALS LIST & DWG UPDATES	NTUA
02	12/12	MATERIALS LIST & DWG UPDATES	NTUA
01	07/05	MATERIALS LIST & DWG UPDATES	NTUA
NO.	DATE	DESCRIPTION	BY
NAVAJO TRIBAL UTILITY AUTHORITY			
SCALE:	NONE	REVISION:	BY: DATE:
DATE:	11/14	12/12	07/05
APPROVED:			
TITLE: PLC CONTROL PANEL		SHEET 5A OF 6	
W/ SWNG OUT PANEL			

THE NAVAJO NATION

McKINLEY COUNTY, NEW MEXICO

THOREAU BACA WELL CONNECTION
SECTION 19, T. 14 N., R. 13 W.
PLC CONTROL PANEL (5A OF 6)

SOUDER, MILLER & ASSOCIATES

Engineering • Environmental • Geomatics
Serving the Southwest & Rocky Mountains
5454 Venice Avenue NE, Suite D
Albuquerque, NM 87113
Phone (505) 299-0942 Toll-Free (877) 299-0942 Fax (505) 293-3430
www.soudermiller.com

STANDARD
DRAWING

THIS DRAWING IS INCOMPLETE
AND NOT TO BE USED FOR
CONSTRUCTION UNLESS IT IS
STAMPED, SIGNED AND DATED

Designed
TTT

Drawn
AAV

Checked
JMG


Date: March 2021

Scale: Horiz: N/A
Vert: N/A

Project No: 6922883

Sheet:
E-11

P:\0-Baca-Prewitt (6922883)\Baca Thoreau Well Connection\CAD\DWG\6922883-Thoreau Well Conn Electrical.dwg
3/4/2021 1:53:32 PM gaw

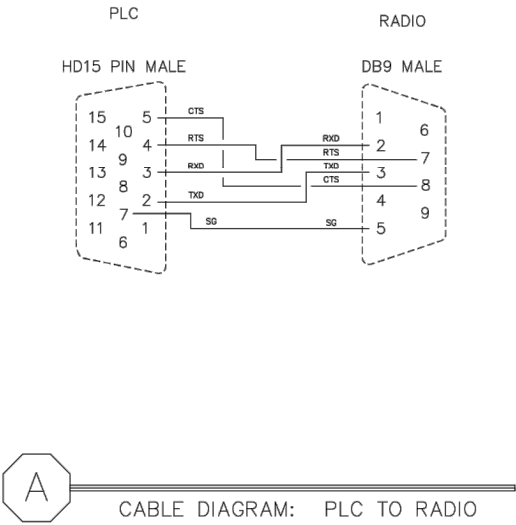

NO.	DATE	DESCRIPTION	BY
03	11/14	DWG. UPDATES	NTUA
02	12/12	DWG. UPDATES	NTUA
01	01/11	DWG. UPDATES	NTUA

SCALE: NONE	REVISIONS	BY	DATE
DATE: .	.	.	.
DRN: .	CHK: .	.	.
APVD: .			

TITLE	PLC CONTROL PANEL	SHEET 6 OF 6
	CABLE PINOUT	



SOUDER, MILLER & ASSOCIATES
Engineering • Environmental • Geomatics
Serving the Southwest & Rocky Mountains
5454 Venice Avenue NE, Suite D
Albuquerque, NM 87113
Phone (505) 299-0942 Toll-Free (877) 299-0942 Fax (505) 293-3430
www.soudermiller.com

THE NAVAJO NATION

McKINLEY COUNTY, NEW MEXICO

THOREAU BACA WELL CONNECTION
SECTION 19, T. 14 N., R. 13 W.
PLC CONTROL PANEL (6 OF 6)

STANDARD
DRAWING

THIS DRAWING IS INCOMPLETE
AND NOT TO BE USED FOR
CONSTRUCTION UNLESS IT IS
STAMPED, SIGNED AND DATED

Designed TTT	Drawn AAV	Checked JMG
-----------------	--------------	----------------

Date: **March 2021**

Scale: Horiz: N/A
Vert: N/A

Project No: 6922883

Sheet:
E-12